### KARUK TRIBE HOUSING AUTHORITY

P.O. Box 1159 • 635 Jacobs Way Happy Camp, CA 96039 Ph: (530) 493-1414 • Fax: (530) 493-1415



1836 Apsuun Street Yreka, CA 96097 Ph: (530) 842-1644 • Fax: (530) 842-1646

### **NOTICE TO BIDDERS**

Date:	May 5, 2023
<b>General Description:</b>	
•	abor, and equipment required for all concrete and masonry work as and documents, for seven (7) homes, on Second Avenue, Happy
<b>Contact Information:</b>	
	hority 1159, Happy Camp, CA 96039 1414, Extension 3110, <u>asupahan@karuk.us</u>
Project Manager:	Doug Goodwin (530) 598-3911 dgoodwin2@karuk.us
Project Name:	Second Avenue Foundations
MANDATORY Site Visit:	Pre-Bid Site Visit NOT REQUIRED
Bid Submission Criteria:	Hand Submission: 635 Jacobs Way, Happy Camp, CA Mail Delivery: PO Box 1159, Happy Camp, CA 96039 Email: asupahan@karuk.us NO FAXES
<b>Bids Due:</b>	Friday, May 19, 2023 by 5pm

### KARUK TRIBE HOUSING AUTHORITY

P.O. Box 1159 • 635 Jacobs Way Happy Camp, CA 96039 Ph: (530) 493-1414 • Fax: (530) 493-1415



1836 Apsuun Street Yreka, CA 96097 Ph: (530) 842-1644 • Fax: (530) 842-1646

### KARUK TRIBE HOUSING AUTHORITY REQUEST FOR LUMP SUM FIXED QUOTATION

### SOLICITATION FOR LUMP SUM FIXED-PRICE QUOTATIONS BASED ON PRICE ONLY (Small Purchases of \$250,000 or less)

Due Date: Friday, May 19, 2023 by 5pm Mandatory Site Visit: Not Required

More Information: Doug Goodwin, (530) 598-3911 dgoodwin2@karuk.us

- 1. The Karuk Tribe Housing Authority (KTHA) requests lump sum fixed-price quotations for all necessary materials, labor, equipment, execution and fees required for all concrete and masonry work as required in provided plans and documents, for seven (7) homes, on Second Avenue, Happy Camp, California as described further in the Scope of Work.
- 2. KTHA is requesting these quotations under the small purchase procedures. This is a less formal, simplified process which will help us to expedite our selection. Because KTHA is following this process, we will not be able to accept quotations that are more than \$250,000.
- 3. Quotations are invited from non-Indian as well as Indian-owned economic enterprises or organizations.
- 4. Quotations may be submitted by email, mail, or hand delivery. All quotations must be submitted to KTHA in writing and can be emailed to <a href="mailto:asupahan@karuk.us">asupahan@karuk.us</a>, mailed or hand delivered to PO Box 1159, 635 Jacobs Way, Happy Camp, CA 96039 by <a href="mailto:Friday, May 19, 2023 by 5pm">Friday, May 19, 2023 by 5pm</a>. NO FAXES will be accepted.
- 5. The Scope of Work is as set forth on Appendix A attached to this Solicitation. Anyone submitting a quotation for this work may visit the job site(s) to ascertain the nature and location of work and to satisfy itself as to the general and local conditions which can affect the work.
- 6. <u>Indian Preference.</u> Any firm seeking Indian preference in this award must provide evidence that it is not less than 51% Indian owned and controlled. If claiming this preference, please contact us immediately so that we can fax you a pre-qualification statement that you must fill out and return within two days of your receipt. KTHA will then review the statement and determine eligibility for preference. All bids must be accompanied by a TERO Compliance Plan as included in Appendix D.
- 7. **Award.** The contract will only be awarded to a responsive, responsible individual or firm. The contract will be awarded to a qualified Indian enterprise submitting the lowest responsive quotation if such quotation is within budgeting limits established for this solicitation and is within the limits identified in the KTHA Procurement Policy regarding Indian preference in contracting. If no responsive quotation by a qualified Indian enterprise is within the above-stated limits, then award will be made to the individual or firm with the lowest responsive quotation.
- 8. All quotations must contain a commitment to provide Indian preference in 1) subcontracting, 2) training, and 3) employment, and must contain a statement describing the methods that will be used to provide such preferences. This statement is part of the submitted quotation. This statement will be evaluated as part of the submitted quotation, and any quotation failing to contain such preference statement or failing to adequately address such preference requirements shall be deemed non-responsive. If you believe it is infeasible to provide Indian preference in subcontracting, training, or employment, you must include in your quotation a certification as to the reasons why.

- 9. The form of Contract which contains the terms and provisions of the contract agreement between KTHA and the individual or firm selected for this work is available for review upon request. By submitting a quotation, you hereby agree that if selected, you shall deliver to the Authority, within the time later designated by the Authority, a properly executed Contract and to be bound by all terms and conditions set forth therein, including but not limited to assurance of performance, completion dates, prevailing wage rates, warranties, other federal requirements, and other terms and provisions as set forth therein.
- 10. All quotations must commit to remaining open for at least 45 days.
- 11. The selected contractor will be responsible for paying all Tribal license fees and taxes, as well as permits that may be required, if any.
- 12. The successful individual or firm on this solicitation must comply with the Tribe's TERO Ordinance, including any licensing requirements. This includes, but is not limited to, paying a 2% TERO fee on the work to be performed. Tribal minimum wage rates shall apply. For a copy of the TERO Ordinance and more information, the Karuk Tribe TERO Director, should be contacted at (530) 493-1600 ext. 2030.
- 13. This solicitation does not commit KTHA to award a contract or to pay any costs incurred in the preparation of quotation or the procurements of supplies. KTHA reserves the right to reject any and all quotations or to re-solicit when it is deemed by KTHA to be in its best interest to do so.
- 14. If there are any questions, please contact <u>Doug Goodwin, Project Manager (530) 598-3911,</u> <u>dgoodwin2@karuk.us</u> KTHA will let you know the decision of the award.

### APPENDIX A To Request for Lump Sum Fixed-Price Quotation

### SCOPE OF WORK

- 1. Successful bid shall include all necessary materials, labor, equipment, execution and fees required for all concrete and masonry work as required in provided plans and documents, for seven (7) homes, on Second Avenue, Happy Camp, California.
- 2. Work shall be in accordance with applicable sections of Chapter 19 of the Uniform Building Code and all local building codes per plans.
- 3. All concrete shall be a 5 sack mix and have a minimum compressing strength of 2500 psi at 28 days.
- 4. Reinforcing steel, as required, shall be properly anchored and tied in place before pouring concrete. Lap all splices a minimum of 32 bar diameters. Reinforcing steel shall conform to ASTM designation A-615, Grade 40.
- 5. Bid shall include all trenching necessary, including backfill.
- 6. Bidders shall acknowledge that the seven (7) homes will be erected at separate times, shall be flexible to scheduling, and shall account for such in their bids (ex; multiple trips required). Successful bidder will be given two weeks notification that work is ready to begin.
- 7. Questions may be directed to Doug Goodwin, Project Manager at (530) 598-3911.
- 8. No pre-bid site visit is required.
- 9. Bidder shall have appropriate license, certification, and insurance for the work to be performed.
- 10. Proposals <u>must be received no later than 5pm on Friday, May 19, 2023</u> at the Happy Camp KTHA Office located at 635 Jacobs Way, Happy Camp, CA 96039. Proposals may be submitted electronically to <u>asupahan@karuk.us</u> Faxes will NOT be accepted.
- 11. All bids must include a TERO fee of 2%, and Tribal wage rates (as attached) and Indian preference will apply.

# APPENDIX A To Request for Lump Sum Fixed-Price Quotation

### TRIBAL WAGE RATES

KARUK TRIBAL WAGE	RATES
Updated April 20	11
Position:	Rate:
CARPENTER	17.00
CEMENT MASON	16.00
ELECTRICIAN	18.00
LABORER	12.00
PAINTER	13.00
PLUMBER	18.00
ROOFER	14.00
SHEET METAL WORKER	18.00
BRIDGE BUILDER	17.00
PILE DRIVER	23.00
MILLWRIGHT	18.00
LINE CONSTRUCTION	22.00
COMMUNICATION SYS	18.00
HEAVY EQUIP OPERAT	16.00
IRON WORKERS	17.00
PLASTERER	16.00
BRICK TENDER	16.00
LANDSCAPE/GARDEN	12.00
DRYWALL FINISHER	16.00
GLAZIER	14.00
SOFT FLOOR LAYER	15.00
TRUCK DRIVER	13.00
TILE SETTER	15.00
BRICK LAYER	17.00

### <u>APPENDIX C</u> <u>To Request for Lump Sum Fixed-Price Quotation</u>

### LUMP SUM FIXED PRICE QUOTATION

ITEM	PRICE
CULTURAL MONITOR:	\$ 4,000
SUBTOTAL:	\$
TERO FEE (2% OF SUBTOTAL):	\$
TOTAL QUOTATION AMOUNT:	\$
Respectfully Submitted by,	
Signature:	
Name/Title:	
Firm:	
Address:	
License Number:	
Phone Number:	

## APPENDIX D To Request for Lump Sum Fixed-Price Quotation

## TRIBAL EMPLOYMENT RIGHTS OFFICE COMPLIANCE PLAN FOR BIDDERS

Bidder/Employer Name:	
Mailing Address:	
City, State and Zip Code:	
Contact Person:	Phone Number:
E-mail:	
Bid Amount: \$	TERO Fee (2%): \$
RIGHTS OFFICE (TERO) AND _ HEREINAFTER KNOWN AS "EM	WEEN THE KARUK TRIBE'S TRIBAL EMPLOYMENT  MPLOYER" CONDUCTING COMMERCE AND HIN THE ANCESTRAL TERRITORY OF THE KARUK
• Employer shall provide the comp	leted compliance plan with the submission of bid.
• Upon notification of the award, E any work to be performed.	imployer shall contact the TERO Office within ten (10) days prior to
	Office and Contract/Project Manager immediately, in writing, ontractor changes to obtain approval prior to working on the job site.
contractors, sub-contractors, emp	to comply with the requirements and procedures in the selection of loyees and recruitment of viable Indian applicants in accordance ent Rights Ordinance and the Karuk Tribe's Workforce Protection
no omissions in the completion of the	ries the position information is true and correct and there have been labor force projections. Falsification of the information provided as and/or debarment with the Karuk Tribe.
Employer Signature	Date

### PRE-AWARD LABOR FORCE PROJECTION

**Core Crew:** Is defined as a member of a business, Contractor or Subcontractor's crew who is a regular employee and is <u>in a supervisory</u> or other key position such that the employer would face a serious financial loss if that position were filled by a person who had not previously worked for that employer.

<u>All other positions</u> will be filled by the TERO office unless sufficient justification can be made that they are not replaceable for the work that is to be done or unless TERO does not have an individual to refer.


Job Title/ Years w/Company/Justification:

List Core Crew (Full Name):

List Native American Contractors/Sub-con	tractor	s to be hired for this Project:	
<u>List Native American Contractors/Sub-con</u>	tractor	s to be hired for this Project:	
Contractor/Sub-contractor	tractor		
	tractor	s to be hired for this Project:  Work to be Performed:	
Contractor/Sub-contractor	tractor		

### <u>List Non-Native Contractor/Sub-contractors to be hired for this Project:</u>

Contractor/Sub-contractor Contact Person, Phone # and E-mail:	Work to be Performed:
Contact Person, Phone # and E-man.	work to be refformed.
through the TERO Skills Bank. If Employer is	6 of all its open positions/Sub-contractors for this project unable to hire 100% then company representatives will to comply with this hiring requirement will result in
Job Title/Sub-contractor Needed:	Skills Required:
-	
Number of positions to be filled for this project	:
Contact person/info for job referrals:	
Date TERO referrals needed:	Job start date:
For Internal Use Only:	
Contract Number #: Projec	et Manager:
TERO Office Approval	Date:
Comments:	

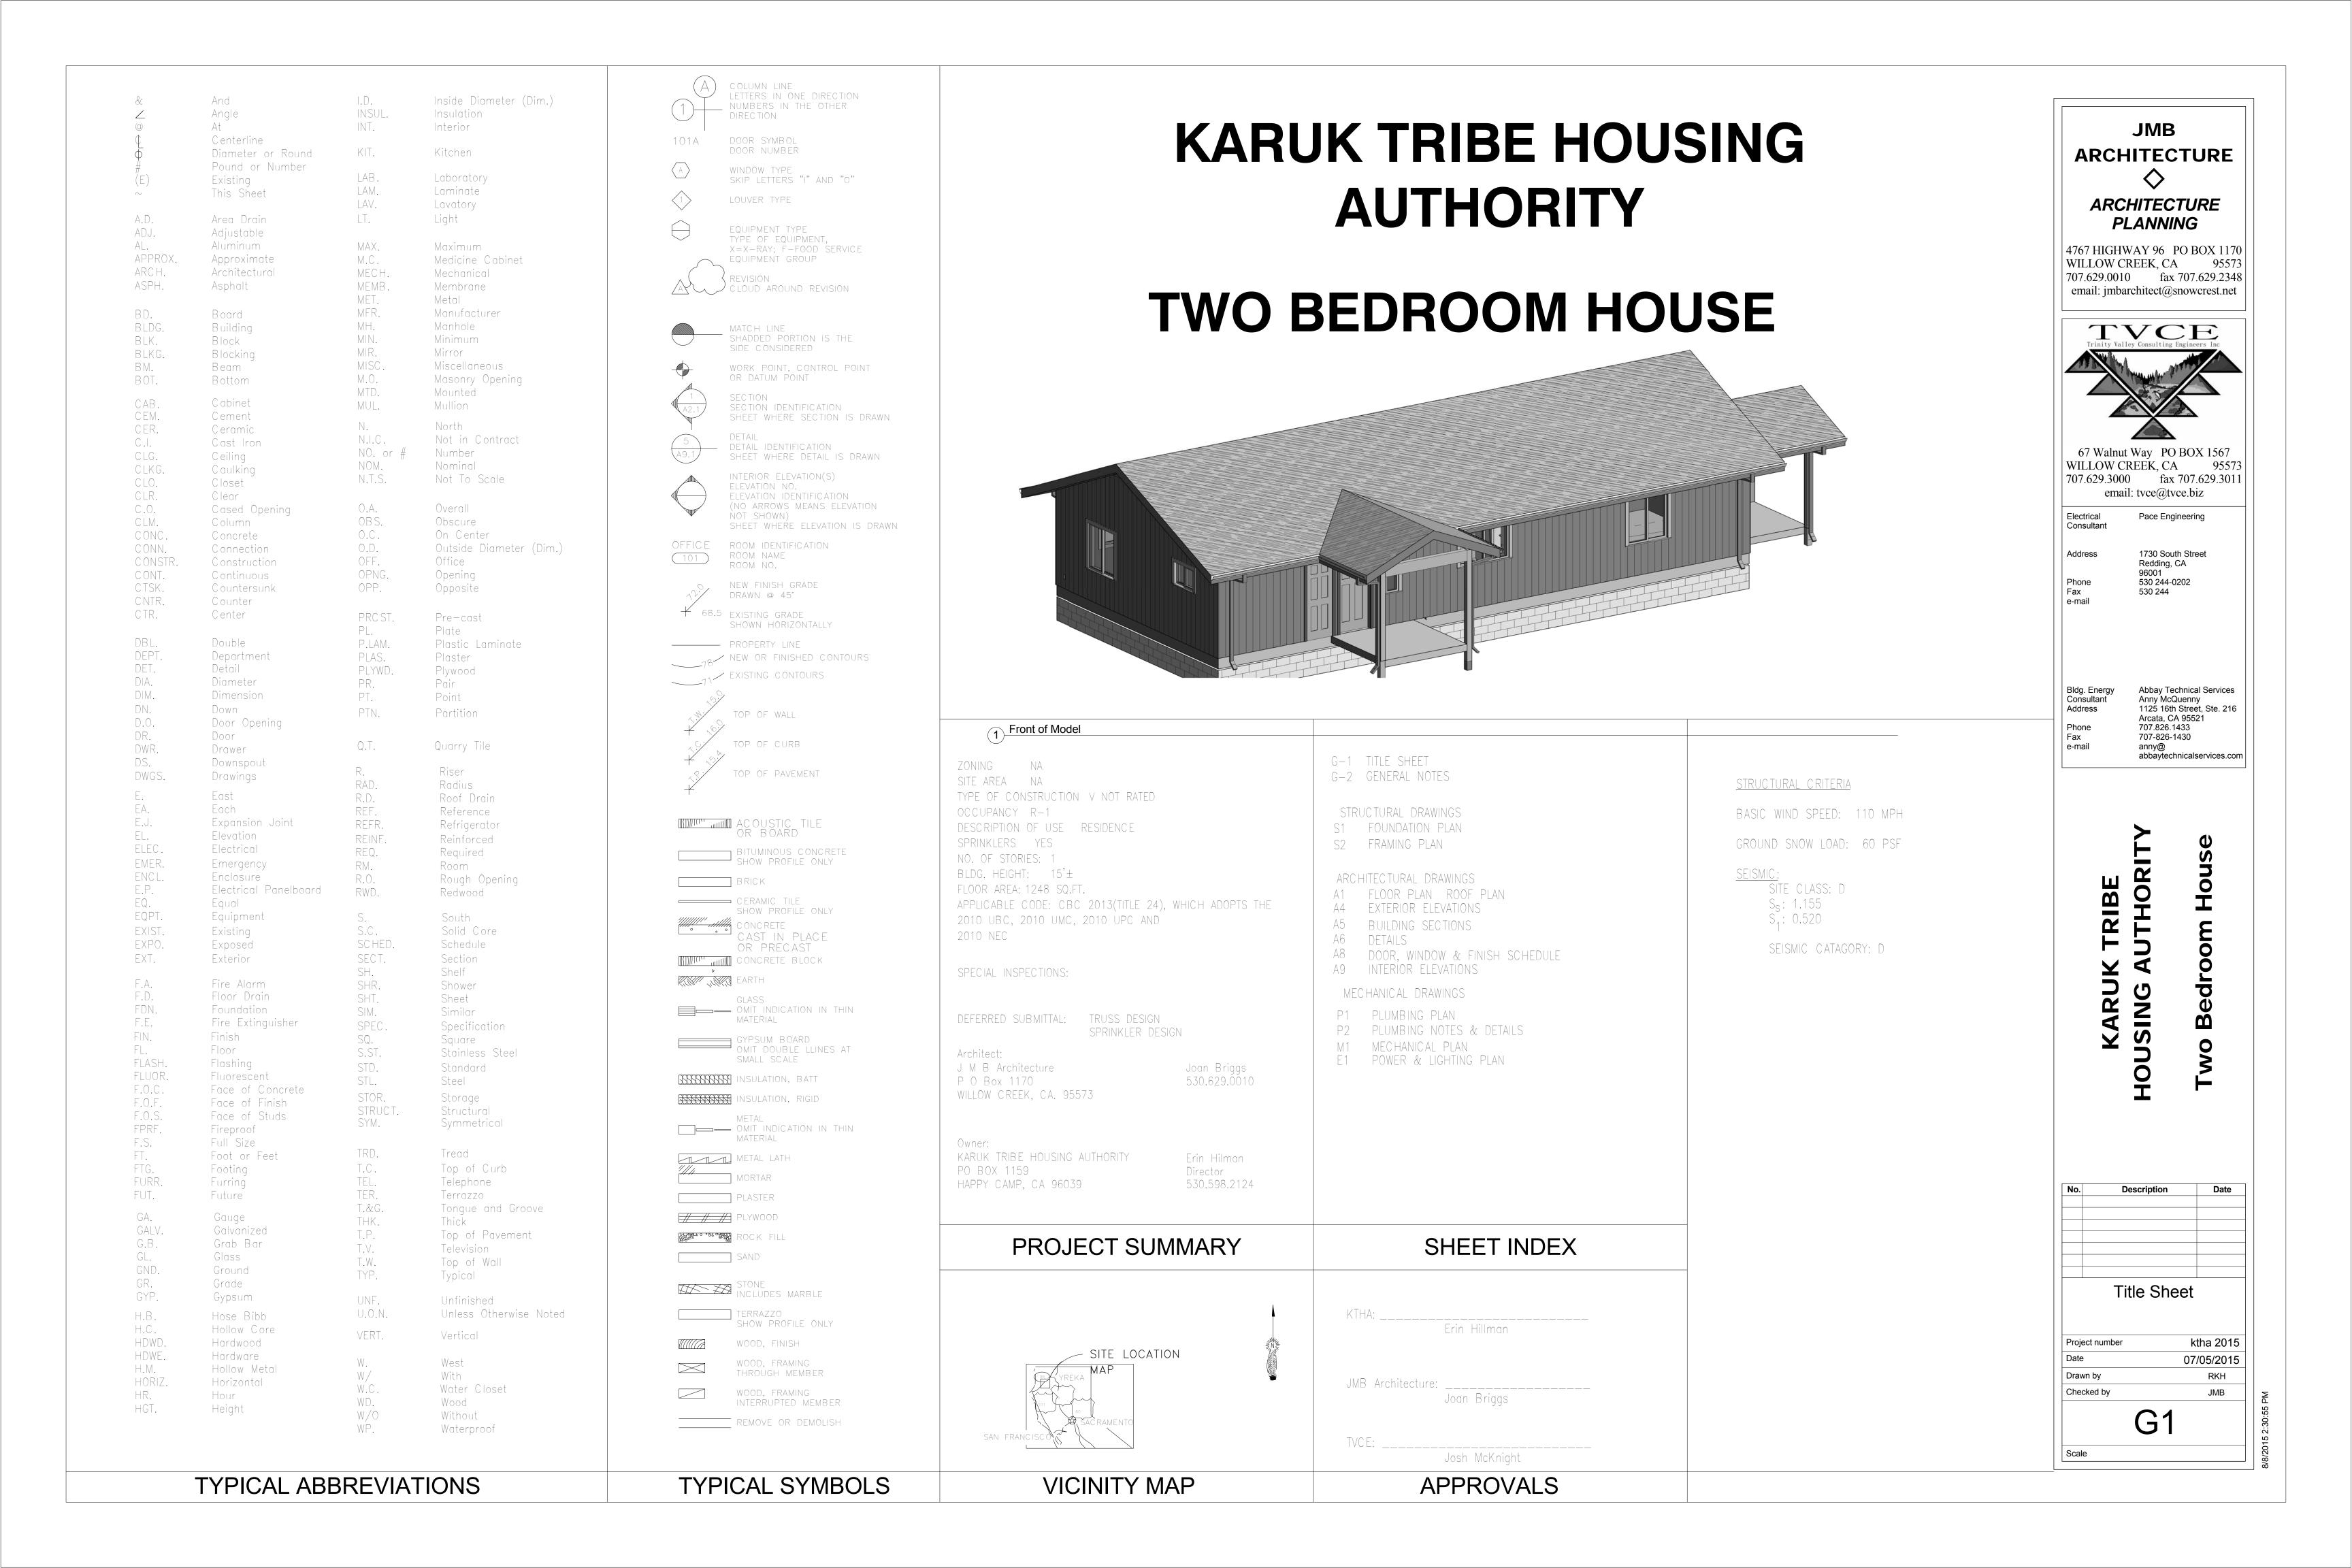

1. DO NOT SCALE DRAWINGS

- 2. The drawings and specifications, and copies thereof are legal instruments of services for use by the owner and authorized representatives on the designated property only.
- 3. All work shall be executed in accordance with the 2010 edition of the California Building Code and/or all other governing agencies requirements. 4. Contractor shall comply with the regulations of "Occupational Safety and Health Act."
- 5. All dimensions and conditions shall be checked and verified on the job site by the contractor before work begins. Any errors, omissions, or discrepancies shall be brought to the attention of the architect and owner before construction begins.
- 6. In the event there are found discrepancies or ambiguities in or omissions from the specifications or the drawings, or should there be doubt as to their meaning or intent, the Architect shall be notified, and shall provide a written clarification prior to the commencement of construction or the purchasing of the materials. Failure on the part of the Contractor to follow this procedure shall relieve both the Architect and the owner of damages, costs, and time delays created by these conditions.
- 7. Contractor shall examine the condition of the project area and verify the sizes and locations of existing facilities at the site, report any discrepancies between the drawings and existing conditions to the owner and the architect, and shall not commence until the conditions are further clarified or authorization to proceed is given.
- 8. Dimensions shown on the drawings are to centerline of column or face of stud, unless otherwise noted.
- 9. Work shall conform to all local, state, and federal codes and ordinances in effect and all safety provisions shall be strictly adhered to.
- 10. There will be no substitutions without the Owner's written prior approval. 11. The Architect makes no guarantee for products identified by trade name or manufacturer, nor their availability; however, the Contractor shall be
- responsible for meeting the performance requirement of the specification. 12. Contractor shall be responsible for and obtain all permits and licenses
- and pay required fees. Certificates of insurance for Workers Compensation shall be filed prior to issuing of permit.
- 13. Each Contractor shall quarantee, be responsible for and make good any and all defects due to faults of his/her trade for labor, leaks or materials, for a period of one year minimum following the acceptance of the work by the Owner
- 14. All damages to, both on and off property (alleys, sidewalks, curbs, streets, etc.) occurring as a result of construction shall be replaced or repaired by the Contractor at no cost to the Owner.
- 15. No materials or refuse shall be kept outside work area. Provide area for combustible rubbish storage.
- 16. Typical details shall apply where no specific details or sections are given. 17. The Contractor shall be responsible for continuous clean-up of the site
- 18. Abbreviations throughout the plans are those in common usage. Architect will define intent of any in question.
- 19. Provide and maintain Fire Extinguishers as required by the Local fire department field inspector during construction. 20. This project shall comply with title 24 and 2013 UBC, UMC and UPC and

### SITE WORK

- 1. All site work shall comply with any applicable approved drawings or local codes as required. 2. Soils Report not required.
- 3. All excess materials shall be disposed of at the Contractor's expense.
- 4. All concrete curbs and sidewalks shall be installed per the California Department of Transportation Standard Specifications—July 2010, Section 73

### EARTHWORK

- 1. All grading and earthwork shall be executed in accordance with those
- ordinances of the governing agencies 2. Carry all footings into solid natural or compacted soil a minimum of 12" regardless of elevations shown on the drawings.
- 3. All fill material shall be compacted to a minimum 95% relative compaction per Cal 216.

### CONCRETE

- 1. The labor, materials and execution required for all concrete work as indicated on the drawings shall be in accordance with those applicable sections of chapter 19 of the latest adopted editions of the uniform building
- 2. All concrete shall be a 5 sack mix and have a minimum compressive strength of 2500 psi at 28 days.
- 3. Reinforcing steel as required shall be properly anchored and tied in place before pouring concrete. Lap all splices a minimum of 32 bar diameters. Reinforcing steel shall be deformed bars conforming to ASTM designation A-615, Grade 40.

### MASONRY

1. The labor, materials and execution required for all masonry work as indicated on the drawings shall be in accordance with those applicable sections of chapter 21 of the latest adopted editions of the uniform building

1. Use approved metal connectors, joist and rafter hangers, post base and cap connectors as required on plans, by code and Building Inspector.

2. All fasteners and hardware in contact with pressure treated lumber shall be hot-dipped galvanized or stainless steel

- 1. The labor, materials and execution required for all structural steel work as indicated on the drawings shall be in accordance with those applicable sections of Chapter 22 of the latest adopted edition of the Uniform Building Code.
- 2. Structural steel shall conform to the latest specifications of the A.S.T.M. and
- have a min. yield of 36,000 PSI 3. Bolted or welded connections shall conform to A.I.S.C. specifications
- unlss noted otherwise on the drawings. 4. Structural steel not encased in concrete shall be shop painted with one coat of zinc chromate

- 1. All lumber shall be grade marked #2 DF minimum except as noted on plans.
- 2. All posts to be #1 DF. 3. All horizontal lumber shall be #1 DF or better.
- 4. All studs shall be DF standard.
- 5. Plywood shall be DF conforming to PSI-74 U. S. Dept of Commerce, and shall be grade stamped "D.F.P.A."
- 6. Wood bearing directly on concrete shall be pressure treated Doug. Fir or Redwood

### CARPENTRY

- 1. All framing and carpentry shall be done in accordance with those applicable sections of Chapter 23 of the latest adopted edition of the Uniform Building Code and details
- indicated on the drawings. 2. Nailing as per C.B.C. Table 25-Q
- 3. Structural Members shall not be cut for pipe, conduit or etc.
- 4. 2 inch solid blocking shall be placed between joists or rafters at all supports
- 5. Use approved metal connectors, joist and rafter hangers, post base and
- cap connectors as required on plans, by code and Building Inspector.

### MILLWORK

- 1. All Millwork shall be manufactured in accordance with the standards in the latest edition of Chapter 23 of the Manual of Millwork of the Wood Working Institute in the Custom Grade hereinafter specified or as shown on the drawings
- 2. Submit Shop Drawings in conformance to Section 1 "Guidelines for Architectural Millwork Shop Drawings".
- 3. Millwork and installation shall be in accordance with Custom Grade of the Manual of Millwork latest edition 4. Deliver all materials only when project is ready for installation and the General Contractor has provided a clean storage area as defined in the Manual of Millwork

### SHEET METAL

- 1. All sheet metal work shall be in accordance with the latest addition of the "Architecturla Sheet Metal Manual" of the Sheet Metal and Air Conditioning Contractors National Association, Inc. SMACNA
- 2. Flashings, gutters and other galvanized iron (G.I.) shall be 26 gage minimum unless noted otherwise, galvanized hot dip process.

1. Where penetrations are made through the roof, provide watertight assembly

### ROOFING

- 1. Asphalt composition shingles to be installed per mfgr. recommendations. Manufactured by Malarki Lifetime Warranty Comp. Arch. Shingle, or equal, Color selected by Owner
- Or Metal Roof FABRAL SSR 1-1/2",or equal, Color selected by Owner 2. All roofing and flashing materials shall be installed in strict conformance with
- the manufacturer's specification and in accordance with Chapter 15 of the latest adopted edition of the Uniform Building Code.
- 3. All roof and flashing materials shall be installed to form a waterproof system and the roofing contractor shall issue a written guarantee to the Owner to maintain the roofing and all flashings in a watertight condition for a period of two (2) years after acceptance of the project.

- 1. Wall insulation R-13 and R-192. Ceiling insulation R-30
- 3. All insulation shall comply with standards established by the State of California "Energy
- Design Manual" and Energy Regulations of California Administrative Code, Title 25

### WEATHER STRIPPING

1. Comply with title 24 requirements for weather stripping at all openings

### DOORS & WINDOWS 1. See Sheet A-7

- . Vinyl Low E Double paned Windows and Sliding Glass Doors manufacturer selected by KTHA . Exterior Doors 6 Panel Metal Doors with standard Kwickset locks and deadbolts
- 4. Interior Doors 6 Panel HC with Kwickset hardware

- 1. All labor, materials and execution required for the glass and glazing work as indicated on the drawings shall be in accordance with those applicable sections of Chapter 24 of the latest adopted edition of the Uniform Building Code.
- 2. Glass doors, adjacent panels, glazing within 24" of a door, and all glazed openings within 1'-6' of the adjacent floor shall be of tempered glass as
- approved for impact hazard. 3. All windows shall be certified and labled to meet A.N.S.I. infiltration standards

### FINISHES

- 1. Contractor shall supervise all finish work.
- 2. Contractor shall provide galvanic insulation between dissimilar metals.
- 3. All materials and finishes indicated on drawings shall be new, unused, and
- of serviceable condition except as specifically noted.
- 4. Wall and Ceiling materials shall not exceed the flame spread clasifications in UBC table 8-B

### EXTERIOR SIDING

- 1. Siding: LP Siding with 8" grooves
- 2. Trim: primed spruce 3/4"x4" around windows and doors
- 3. Soffit: NA

### GYPSUM WALLBOARD

- 1. The Gypsum Wallboard work shall be done in accordance with the recommendations of ASTM C754,GA 151, GA 201, GA 216 and shall conform with Chapter 25 of the latest adopted
- edition of the California Building Code 2. Interior walls to be finished with orange peel texture through out
- Ceramic tile work shall be in accordance with the best recommended standards of the "Tile Council of America"

- 1. All painting work, which includes back priming, sealing, staining, lacquering or other work reasonable incidential to the painting of all exterior and interior woodwork, plywood, gypboard, sheet metal, ironwork, etc. shall be in accordance with the recommended standards as set forth in the "Painting Specifications" of the Painting and Decorating Contractors Association of America.
- 2. Colors of all areas being patched and repaired shall match existing and all new work shall be as directed and per schedule provided by Contractor
- 3. Paint shall be 100% acrylic, applied per manufacturers recommendations
- and per schedule provided by Contractor and Owner 4. Interior Walls— prime and paint with two coats semi-gloss latex enamel Exterior Walls—one coat primer and two coats eggshell finish Exterior Trim-one coat primer and two coats semi-gloss finish

### CARPET

- 1. Manufactured by NA
- 2. Color as selected by Owner from manufacturers standards. 3. Install in accordance with manufacturers recommendations.
- VINYL
- 1. Manufactured by Armstrong, Product: NA

### 2. Color as selected by Owner from manufacturers standards. 3. Install in accordance with manufacturers recommendations.

### MECHANICAL

- 1. See Mechanical Notes sheet M−1
- 1. See Plumbing Drawings Sheet P-1, P-2

### ELECTRICAL

1. See Electral Drawing Sheet E−1

etc., where indicated or required.

### ENERGY CONSERVATION

1. All work shall conform to the energy conservation requirements set forth in the California Administrative Code, Title 24.

2. See sheet CF1 and CF2 Energy Statement

1. All Pin—type hinges which are accessible from outside a secured area when the door is closed shall have non-removable hinge pins. In addition, they shall have minimum 1/4" diameter steel jamb stud with 1/4" minimum protection unless the hinges are shaped to prevent removal of the door if the hinge pins are removed.

### FIRE PROTECTION

- 1. All smoke detectors to be hard wired with battery backup.
- 2. Penetrations of fire resistive walls, floor ceiling and roof—shall be
- protected as required in UBC Sections 709 and 710. 3. Provide noncombustible blocking behind all fixtures, handles, grab bars,

1. All exits are to be openable from the inside without the use of a key or special knowledge

# **JMB ARCHITECTURE** ARCHITECTURE **PLANNING**

4767 HIGHWAY 96 PO BOX 1170 WILLOW CREEK. CA 95573 707.629.0010 fax 707.629.2348 email: jmbarchitect@snowcrest.net




67 Walnut Way PO BOX 1567 WILLOW CREEK, CA 95573 707.629.3000 fax 707.629.3011 email: tvce@tvce.biz


- 1		
	Electrical Consultant	Pace Engineering
	Address  Phone Fax e-mail	1730 South Street Redding, CA 96001 530 244-0202 530 244
	Bldg. Energy Consultant Address Phone Fax e-mail	Abbay Technical Services Anny McQuenny 1125 16th Street, Ste. 21 Arcata, CA 95521 707.826.1433 707-826-1430 anny@ abbaytechnicalservices.com

# ING


No.	Description	Date
Gl	ENERAL NO	TES


Project number ktha 2015 07/05/2015 Drawn by Checked by JMB

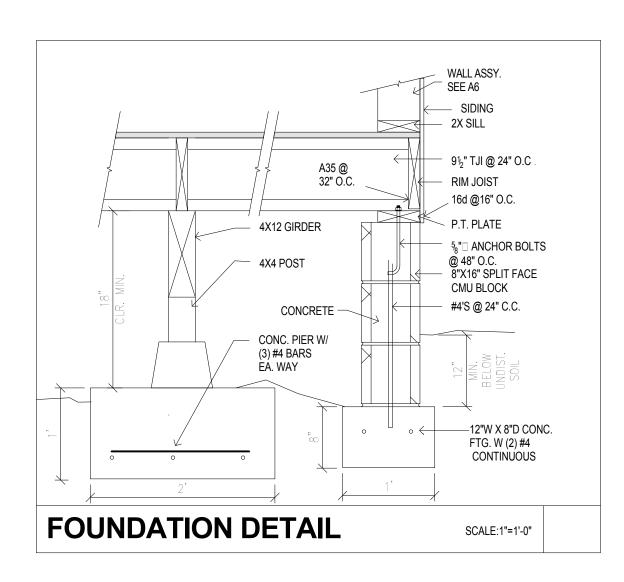

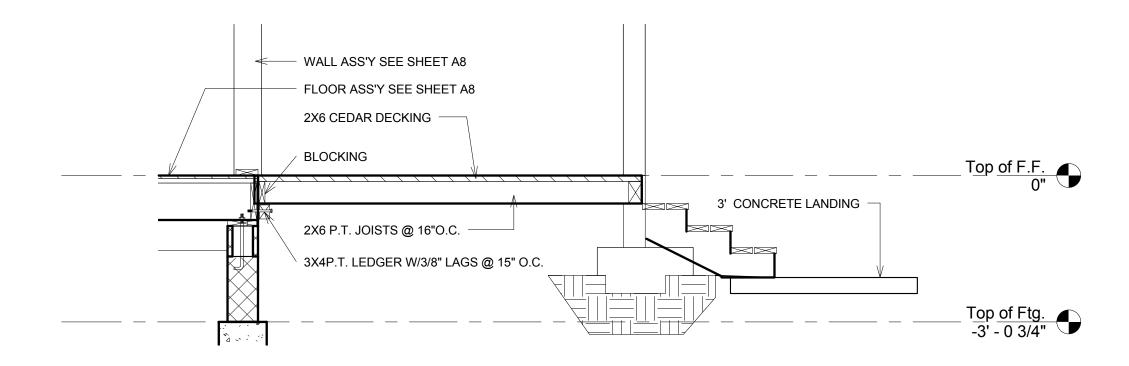


3 FOOTING DETAIL AT DECK 1/2" = 1'-0"

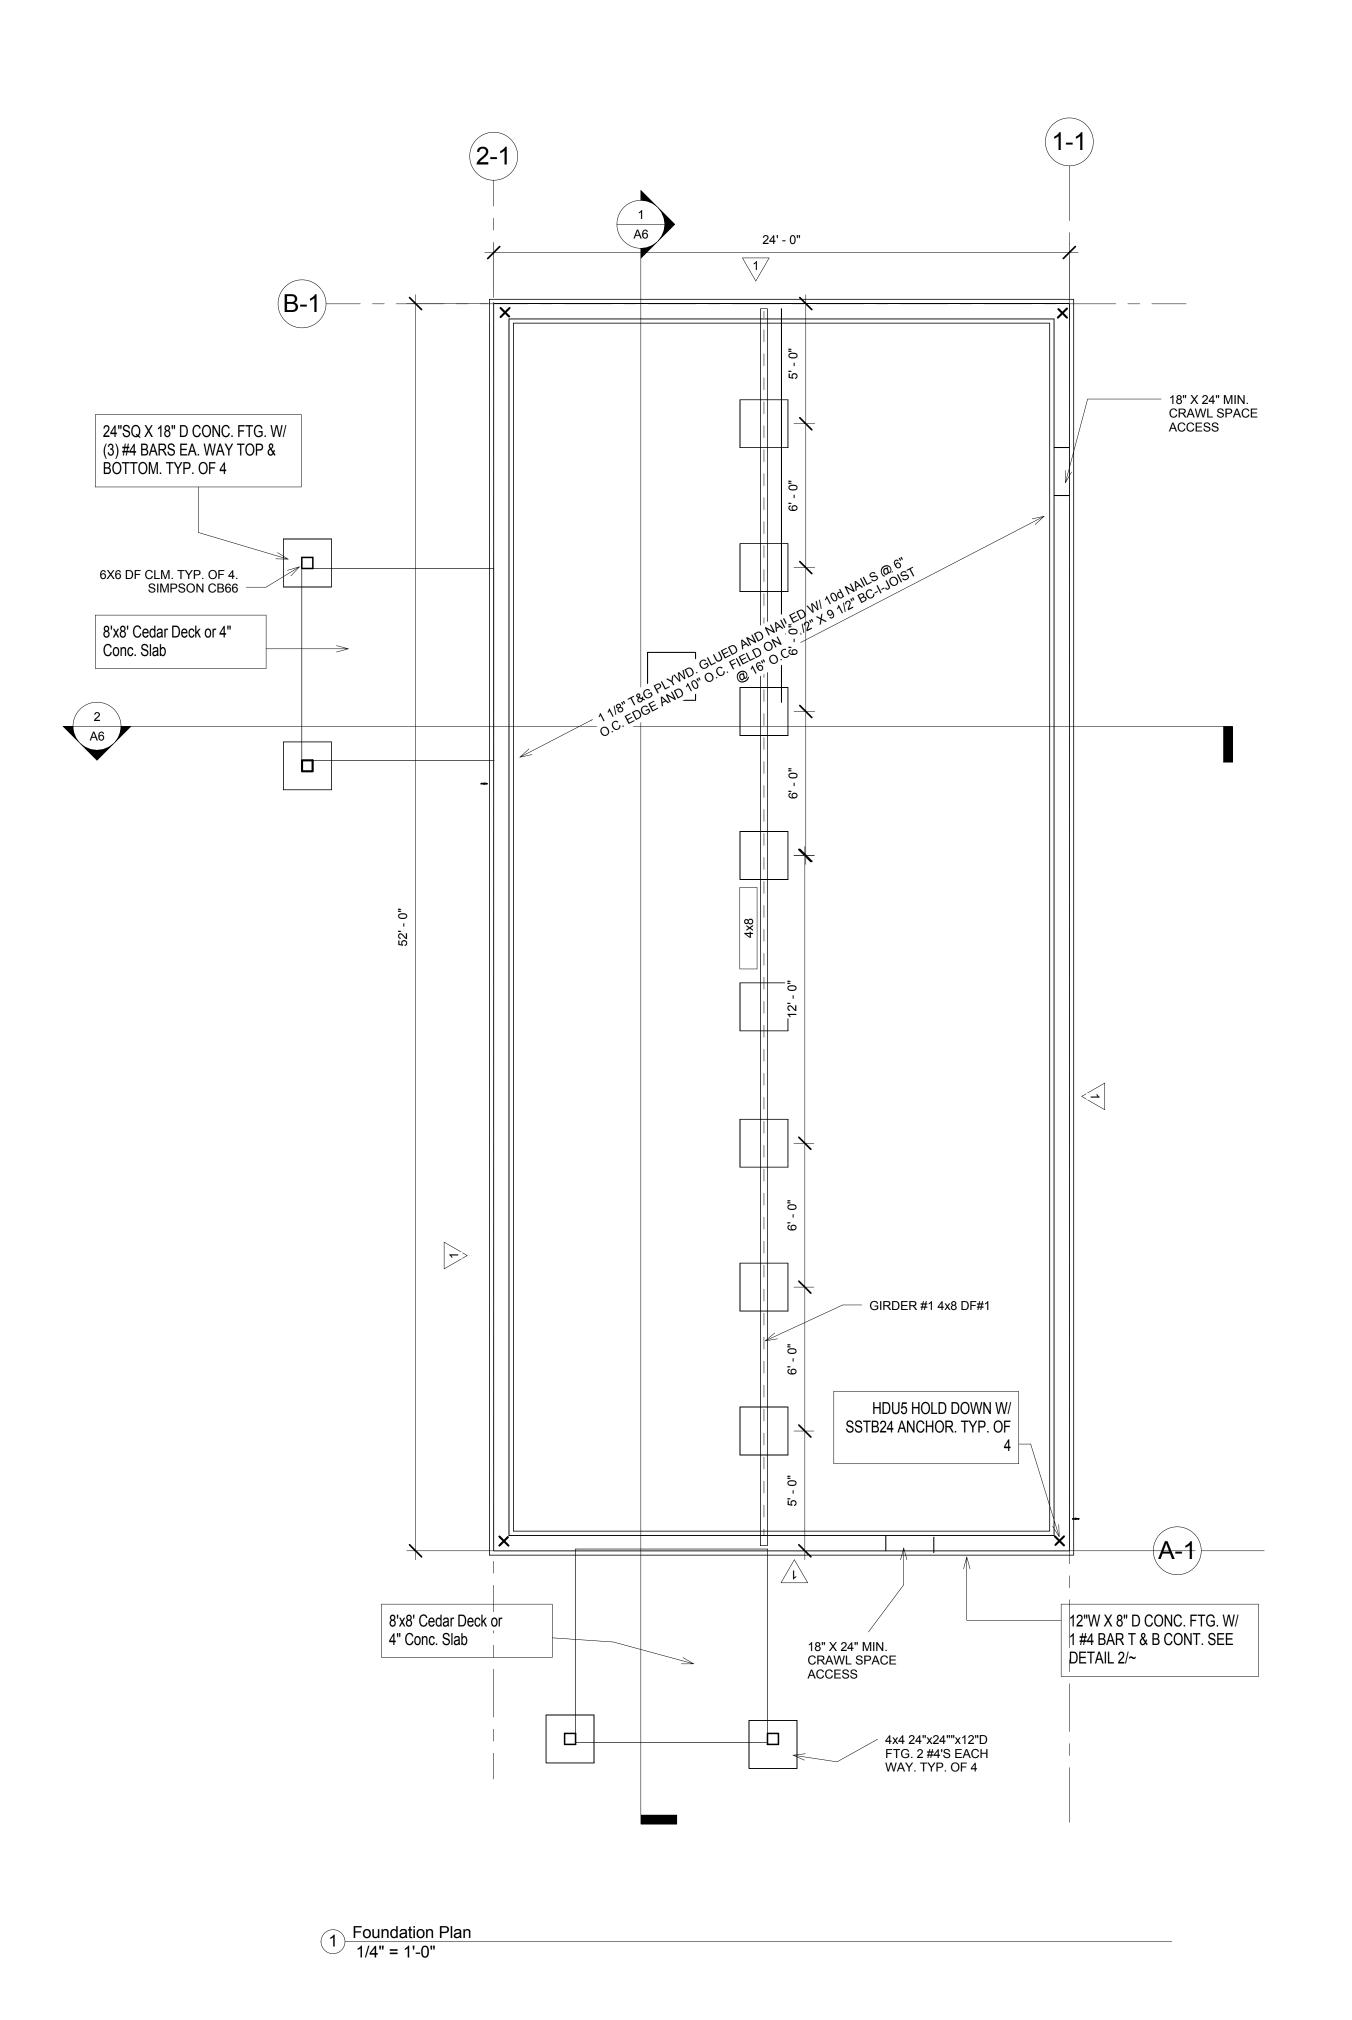


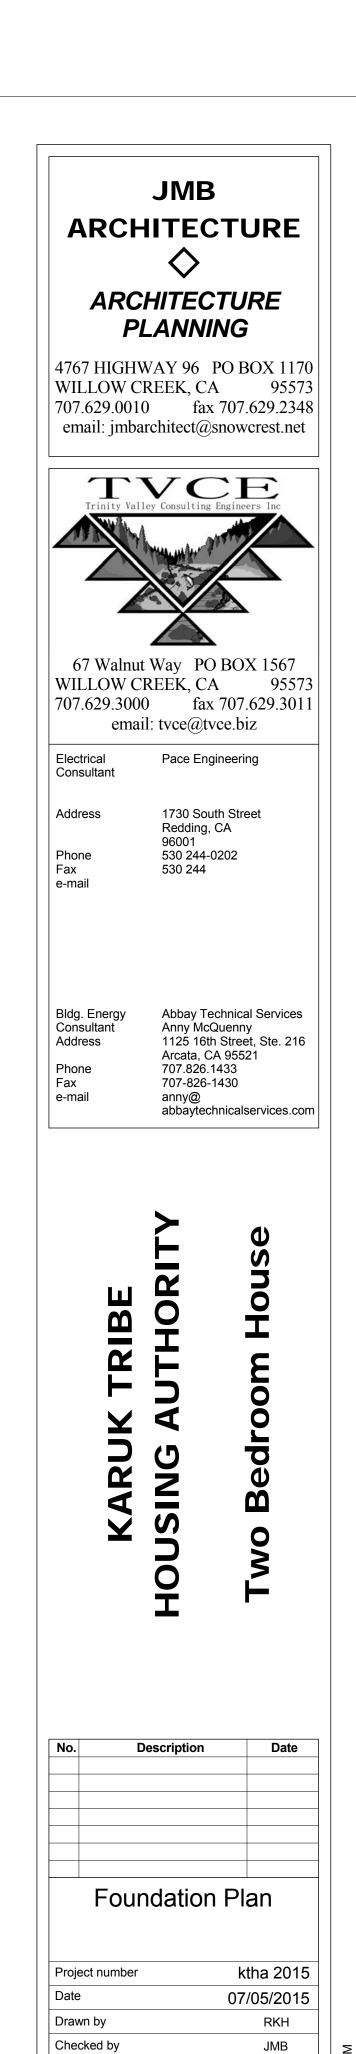


As indicated

Scale

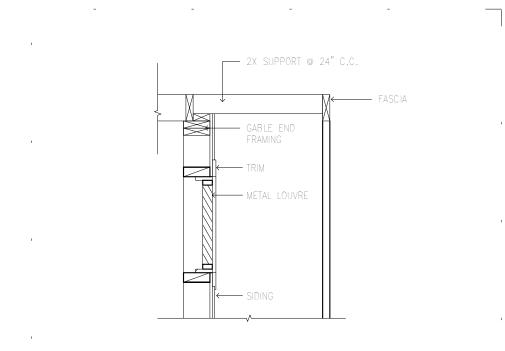


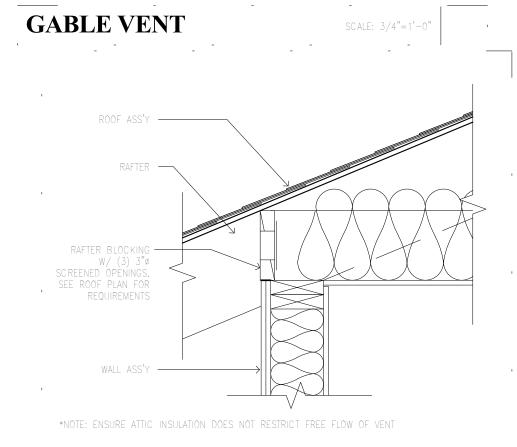


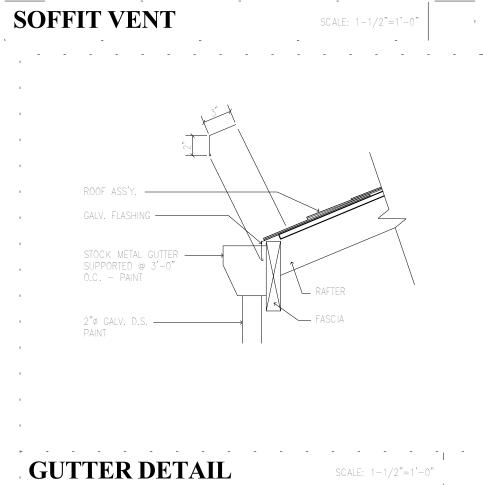


Note: All Headers 6X12 DF #2 U.N.O.

Wall Line	Story	Sheathing	Framing	Nalling	Anchor Bolts	Connections	Other
1-1	1	T-111 Siding	2X6 @ 16" o.c.	8d @ 6" edge,12" field	5/8" X 10" @ 48" o.c.	H2.5 @ EA Truss	
2-1	1	T-111 Siding	2X6 @ 16" o.c.	8d @ 6" edge,12" fleid	5/8" X 10" @ 48" o.c.	H2.5 @ EA Truss	
A-1	1	T-111 Siding	2X6 @ 16" o.c.	8d @ 6" edge,12" field	5/8" X 10" @ 48" o.c.		
B-1	1	T-111 Siding	2X6 @ 16" o.c.	8d @ 6" edge,12" field	5/8" X 10" @ 48" o.c.		

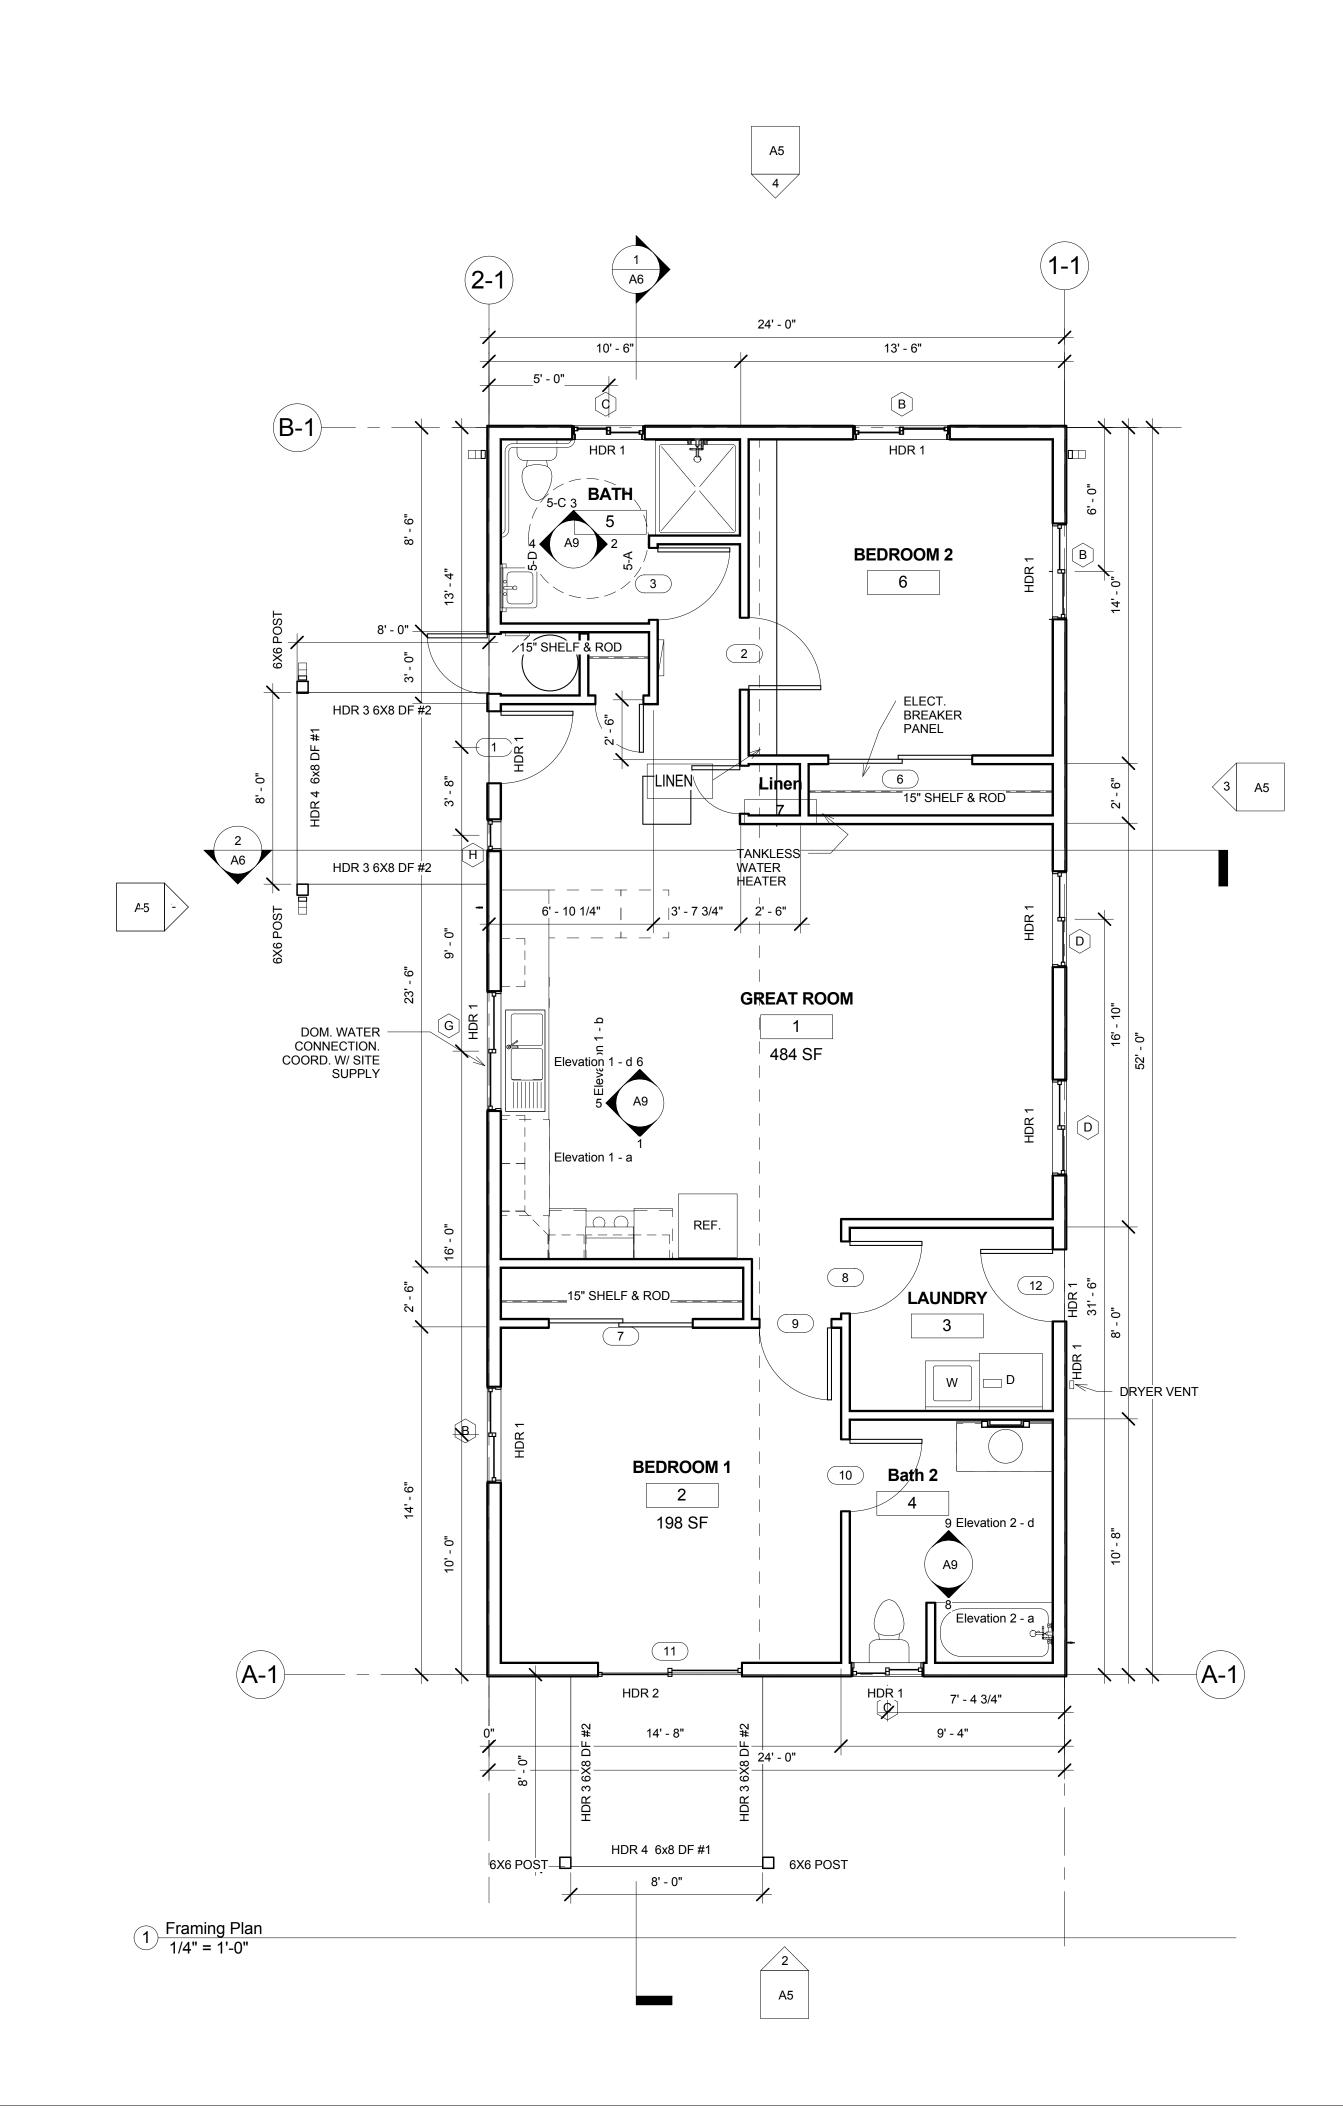

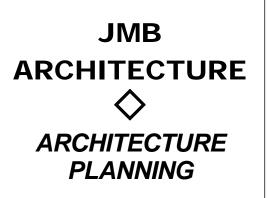

4767 HIGHWAY 96 PO BOX 1170 WILLOW CREEK, CA 95573 707.629.0010 fax 707.629.2348 email: jmbarchitect@snowcrest.net

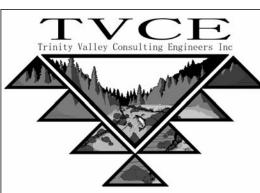

67 Walnut Way PO BOX 1567 WILLOW CREEK, CA 95573 707.629.3000 fax 707.629.3011 email: tvce@tvce.biz

Electrical
Consultant

Pace Engineering

Address

1730 South Street
Redding, CA
96001
Phone
530 244-0202
Fax
e-mail


Bldg. Energy
Consultant
Address
Anny McQuenny
Address
Arcata, CA 95521
Phone
Fax
707-826-1430


Fax 707-826-1430
e-mail anny@
abbaytechnicalservices.com

HOUSING AUTHORITY

No.	Descript	tion	D
	Framin	g Plan	1
Project	Framin		
Project Date		ktl	ha 2 05/2
	number	ktl	ha 2

1/4" = 1'-0"

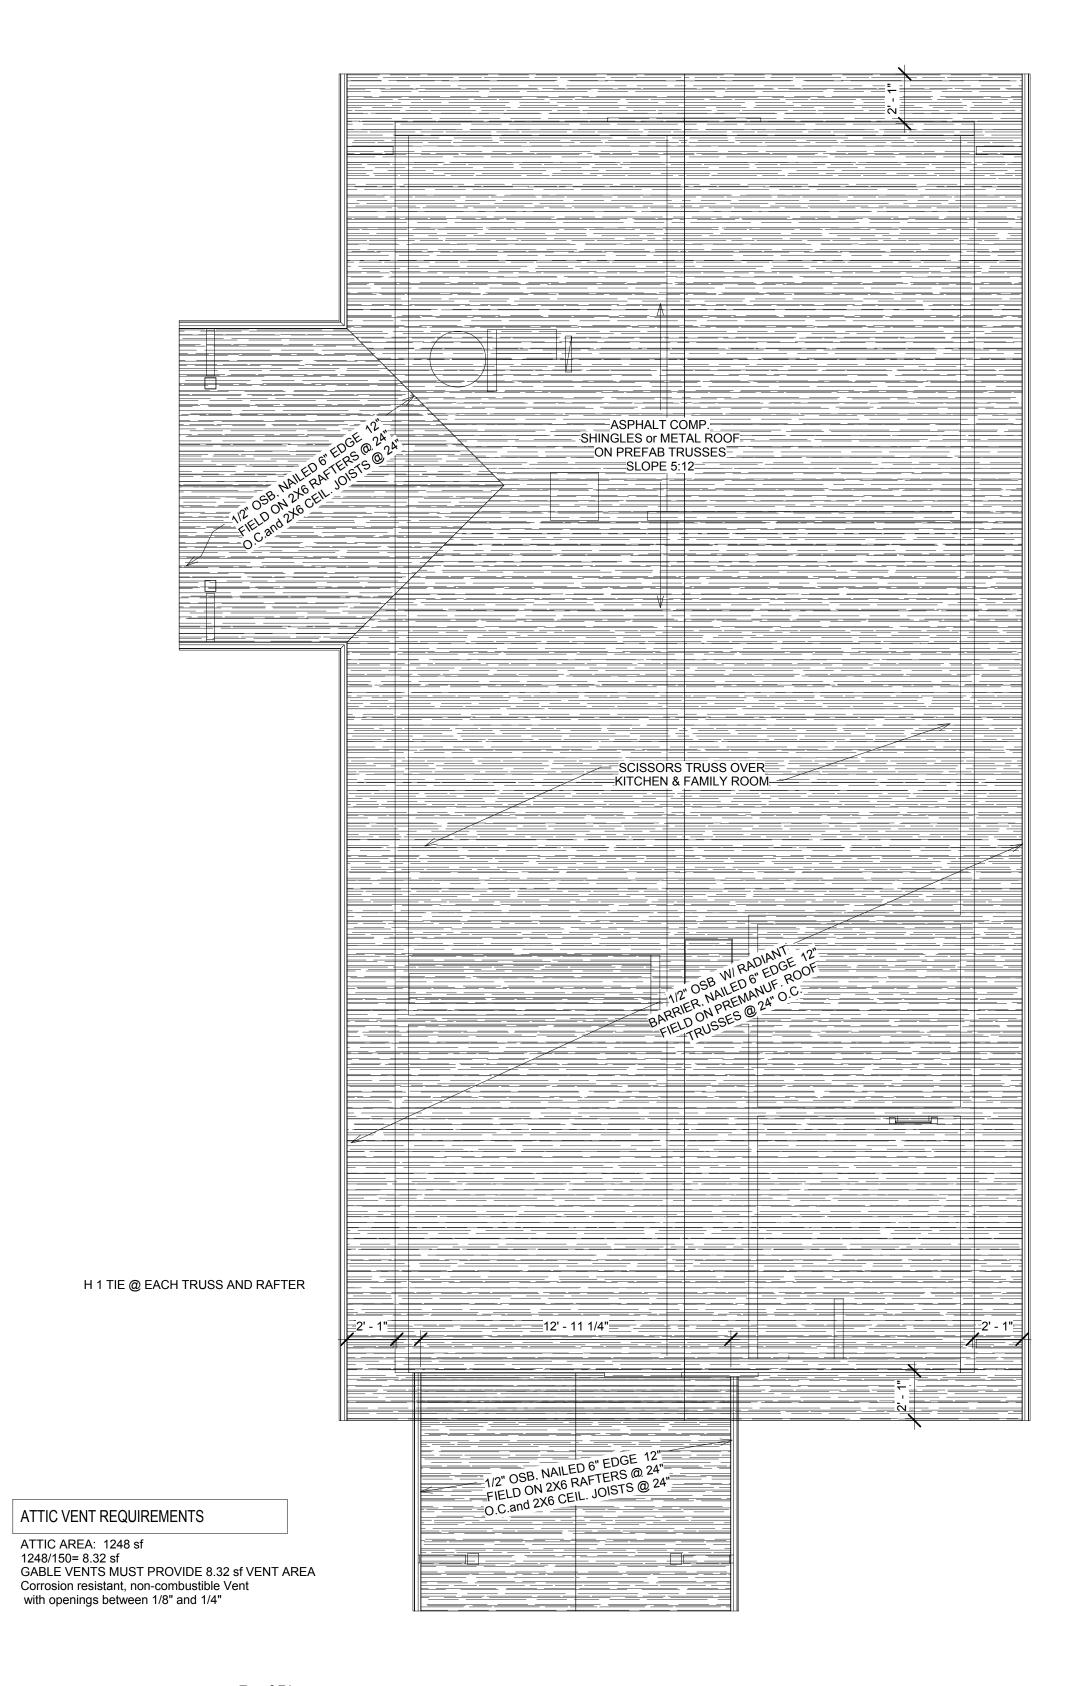

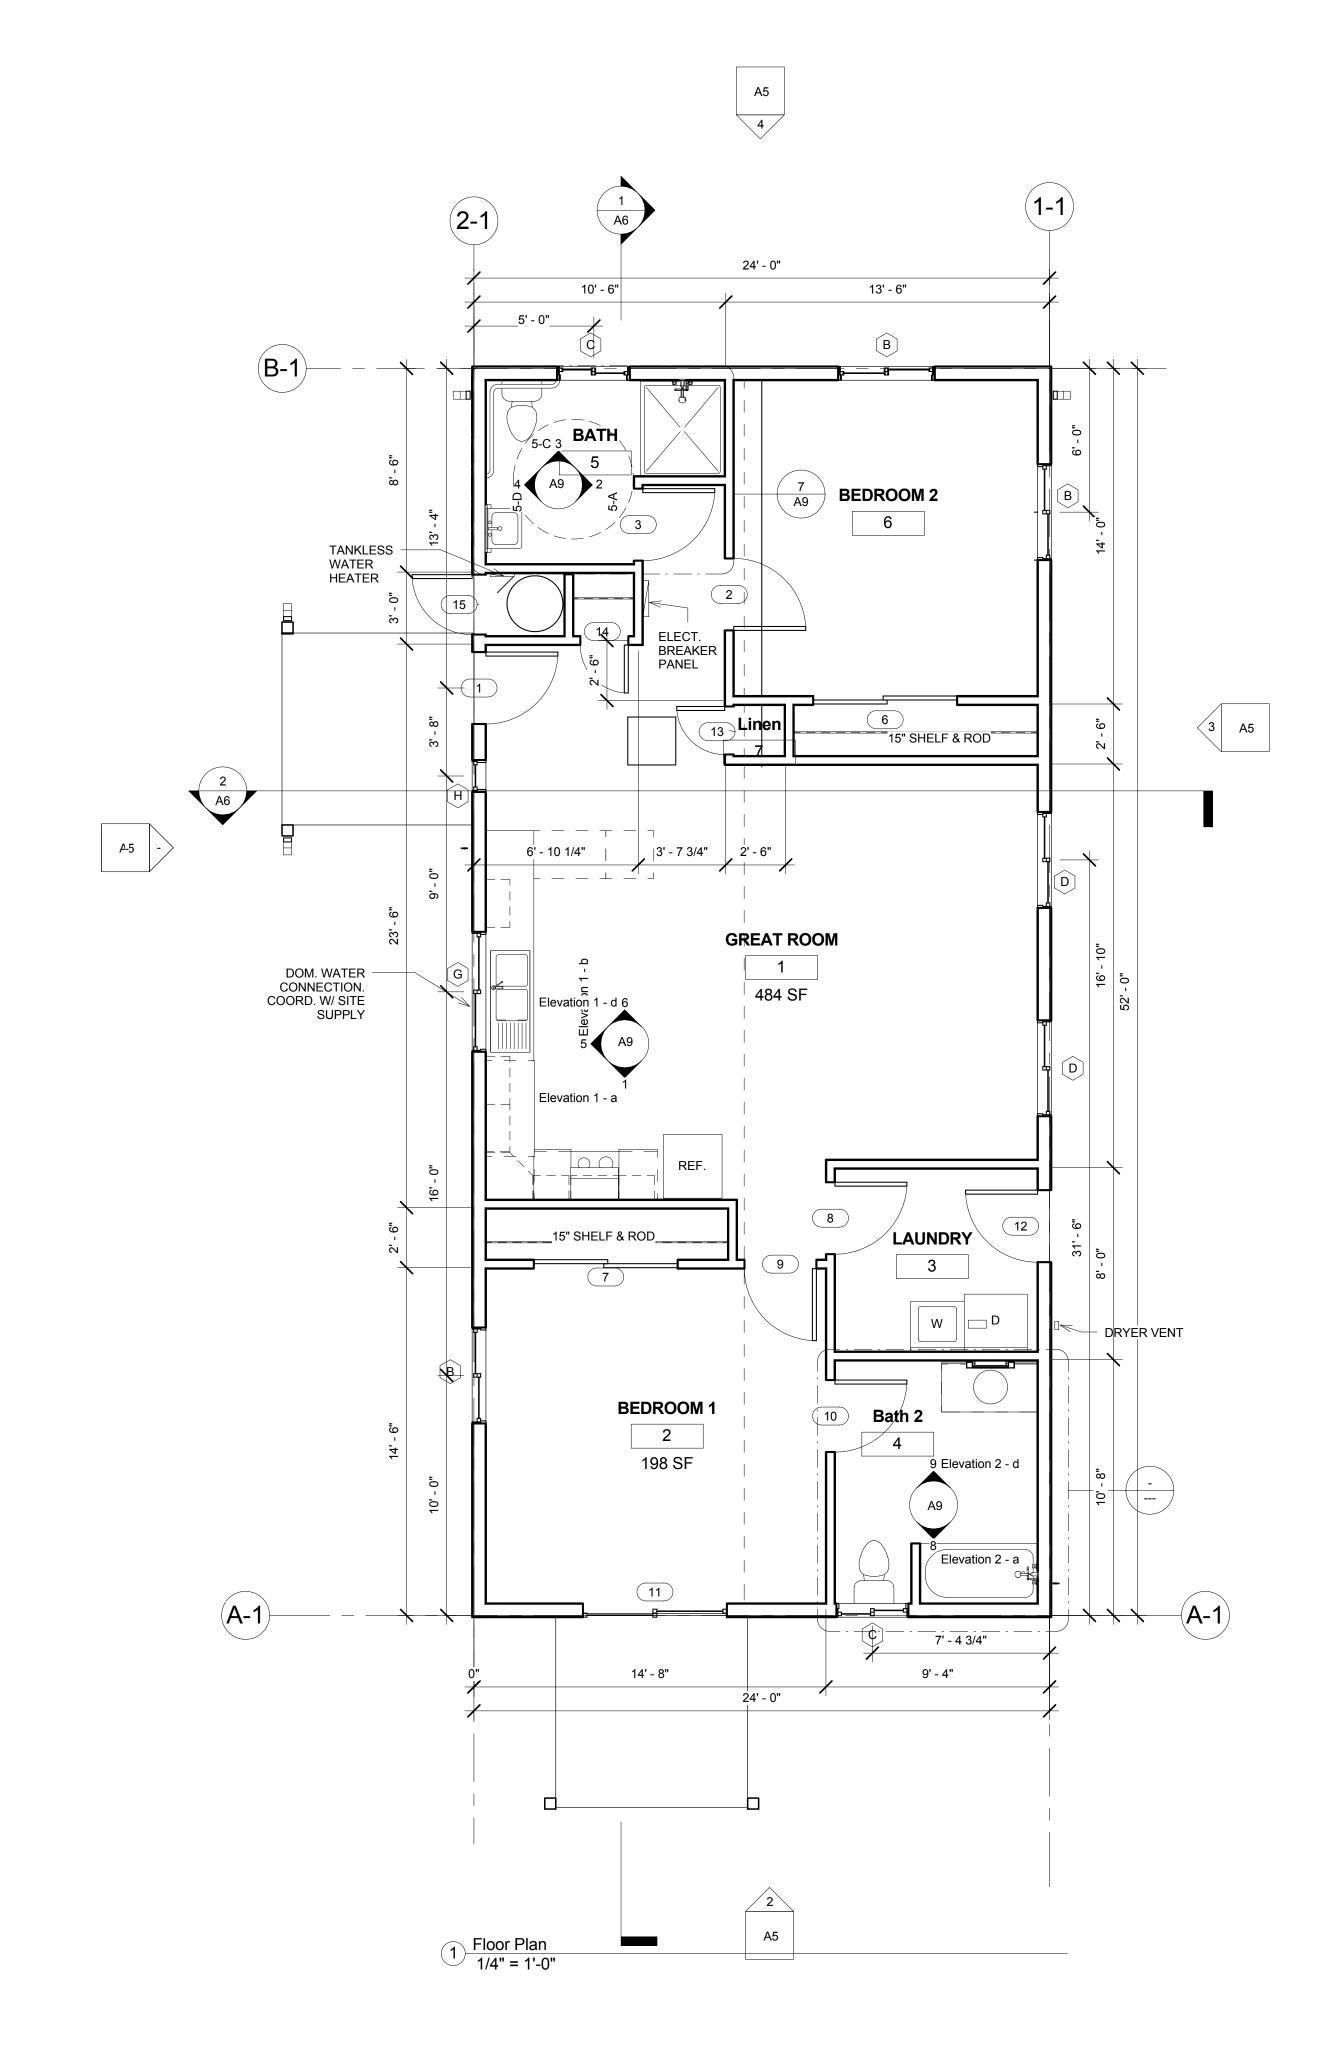



# ARCHITECTURE PLANNING

4767 HIGHWAY 96 PO BOX 1170 WILLOW CREEK, CA 95573 707.629.0010 fax 707.629.2348 email: jmbarchitect@snowcrest.net



67 Walnut Way PO BOX 1567 WILLOW CREEK, CA 95573 707.629.3000 fax 707.629.3011 email: tvce@tvce.biz

Electrical Pace Engineering Consultant

Address 1730 South Street
Redding, CA
96001
Phone 530 244-0202

Phone 530 244-0202 Fax 530 244 e-mail

Bldg. Energy Abbay Technical Services
Consultant Anny McQuenny
Address 1125 16th Street, Ste. 216
Arcata, CA 95521
Phone 707.826.1433

Phone 707.826.1433
Fax 707-826-1430
e-mail anny@
abbaytechnicalservices.com

# KARUK TRIBE SING AUTHORITY Bedroom House

No. Description Date

FLOOR PLAN &
ROOF PLAN


 Project number
 ktha 2015


 Date
 07/05/2015

 Drawn by
 RKH

 Checked by
 JMB

 A 1
 Scale

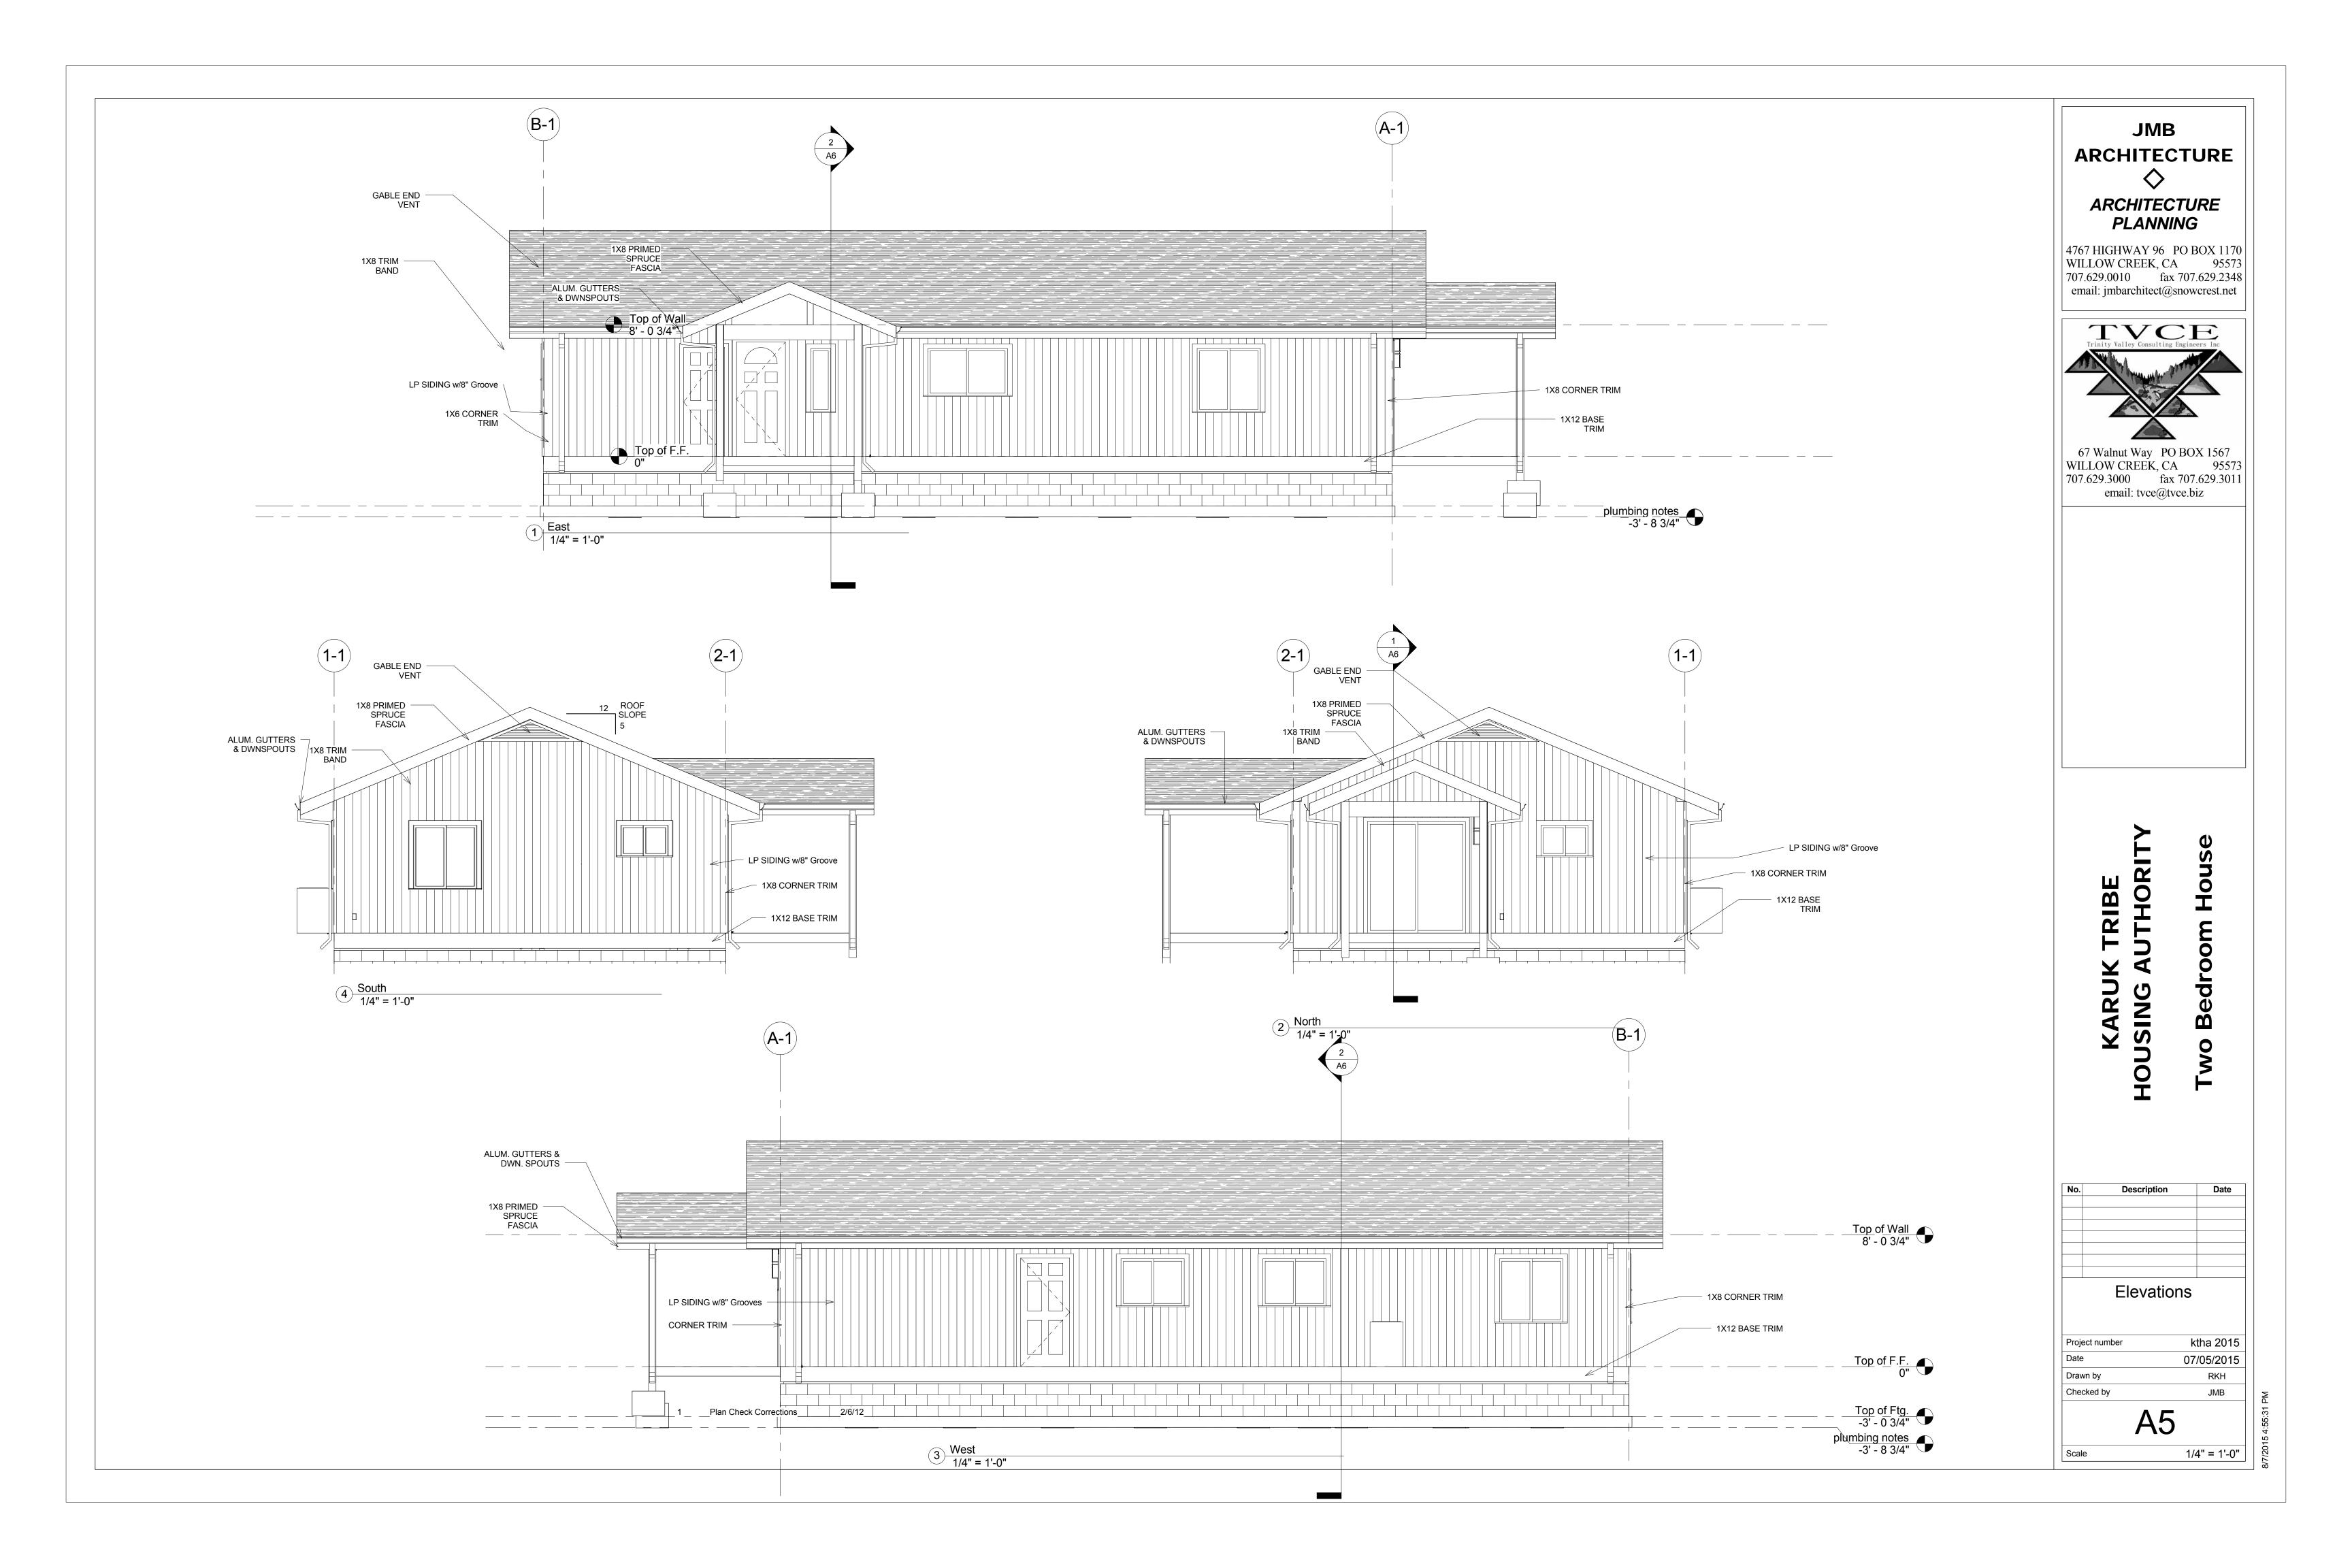

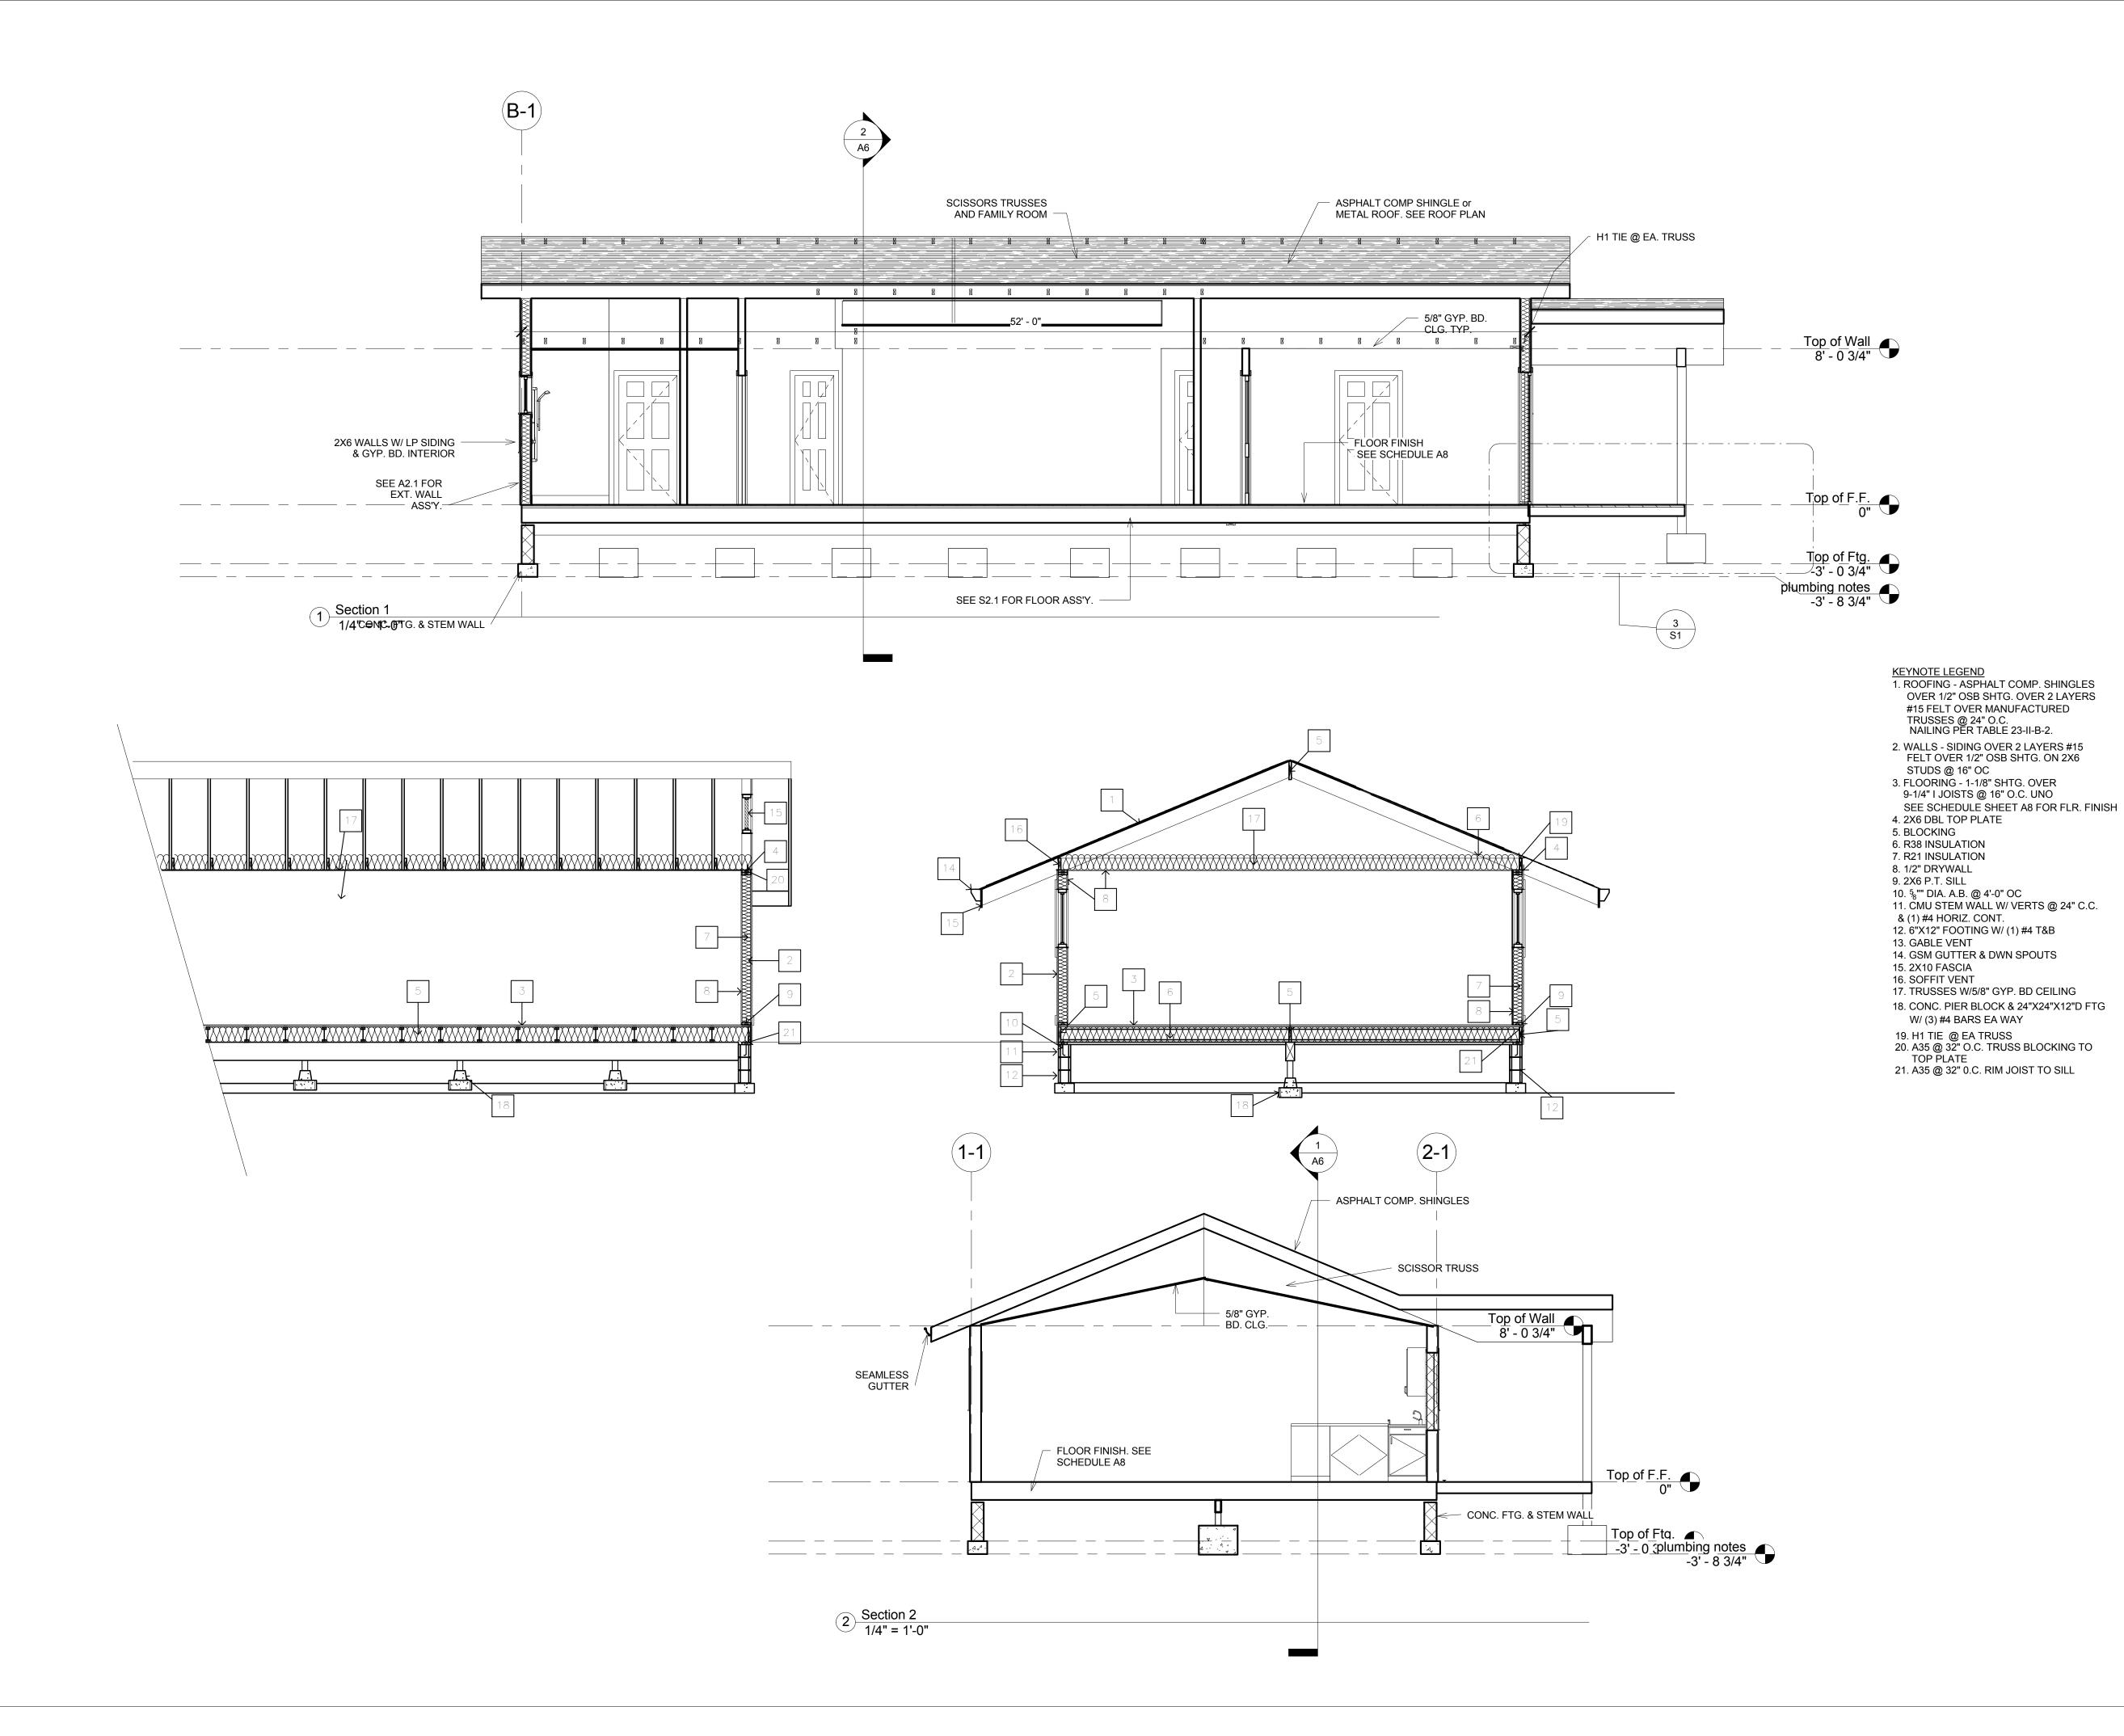

# **JMB ARCHITECTURE** ARCHITECTURE **PLANNING**

4767 HIGHWAY 96 PO BOX 1170 WILLOW CREEK, CA 95573 707.629.0010 fax 707.629.2348 email: jmbarchitect@snowcrest.net



67 Walnut Way PO BOX 1567 WILLOW CREEK, CA 95573 707.629.3000 fax 707.629.3011 email: tvce@tvce.biz

Electrical Pace Engineering Consultant

1730 South Street Address

Redding, CA 96001 530 244-0202

Fax e-mail 530 244


Abbay Technical Services Anny McQuenny 1125 16th Street, Ste. 216 Arca 100, 1422 Consultant Address 707.826.1433

Phone Fax 707-826-1430 e-mail

anny@ abbaytechnicalservices.com

# ARU SING

No.	Description	Date
_	ilding Sec	
	J	
Project num		
Project num		ktha 2015 07/05/2015
		ktha 2015
Date	ber	ktha 2015 07/05/2015
Date Drawn by	ber	ktha 2015 07/05/2015 RKH

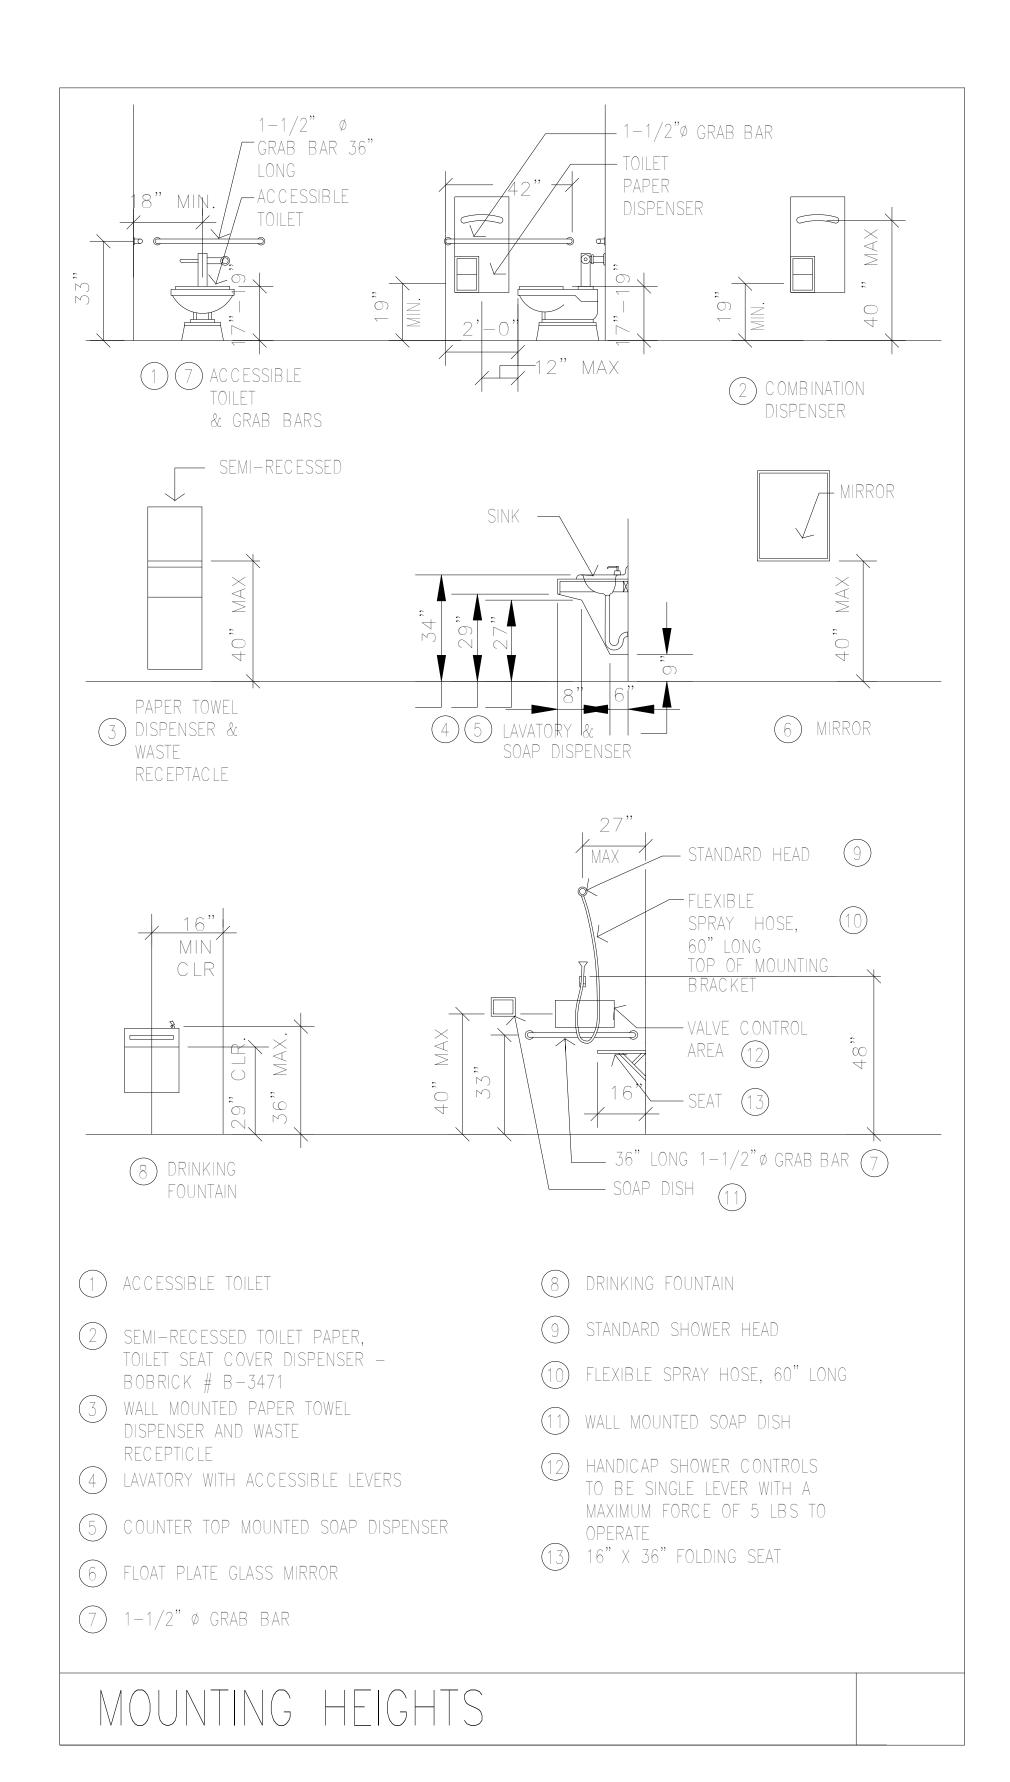

# **JMB ARCHITECTURE** ARCHITECTURE **PLANNING**

4767 HIGHWAY 96 PO BOX 1170 WILLOW CREEK, CA 95573 707.629.0010 fax 707.629.2348 email: jmbarchitect@snowcrest.net



67 Walnut Way PO BOX 1567 WILLOW CREEK, CA 95573 707.629.3000 fax 707.629.3011 email: tvce@tvce.biz

Pace Engineering Consultant 1730 South Street Address Redding, CA 96001 530 244-0202 530 244


Abbay Technical Services Anny McQuenny 1125 16th Street, Ste. 216 Arcata, CA 95521 Address Phone Fax 707.826.1433 707-826-1430 e-mail


anny@ abbaytechnicalservices.com


# UTHORI


Description Details ktha 2015 Project number 07/05/2015 Drawn & NOTED **A7** 

TRIBE KARUK HOUSING AI

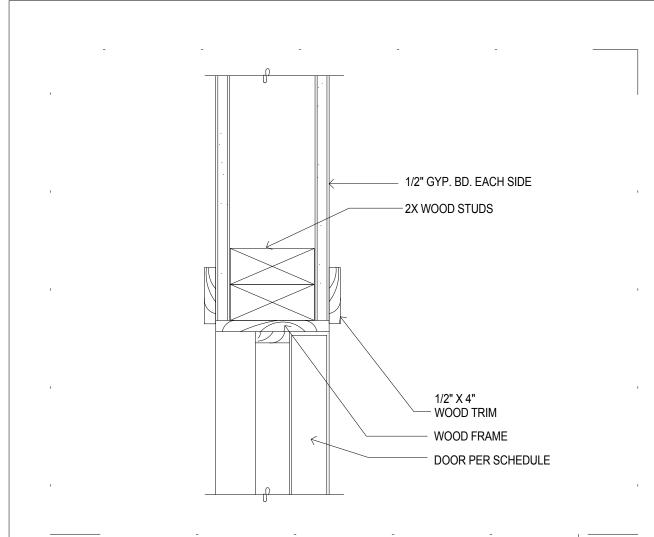

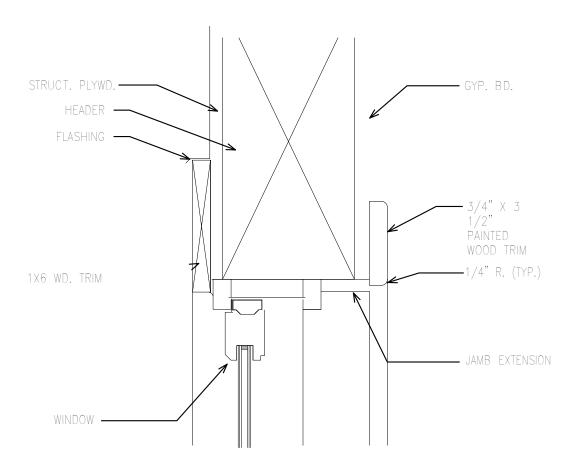

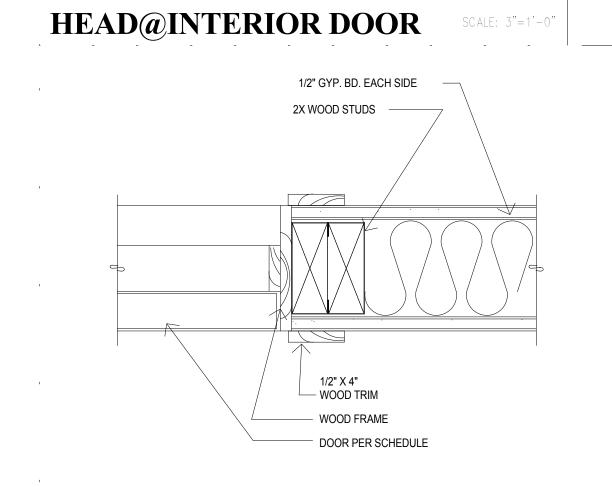


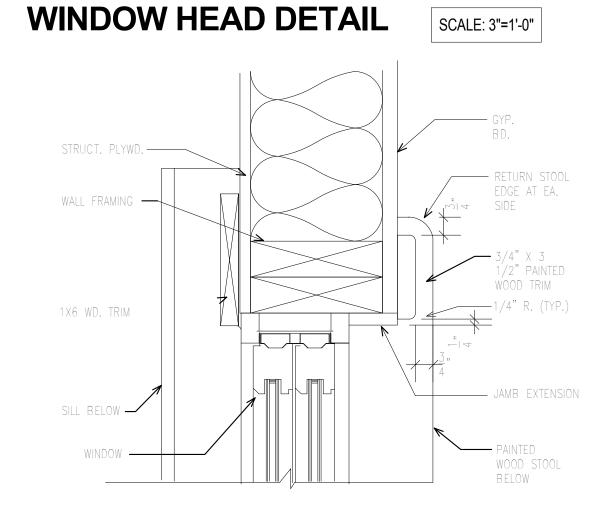

SCALE: 3"=1'-0"



THRESHOLD DETAIL

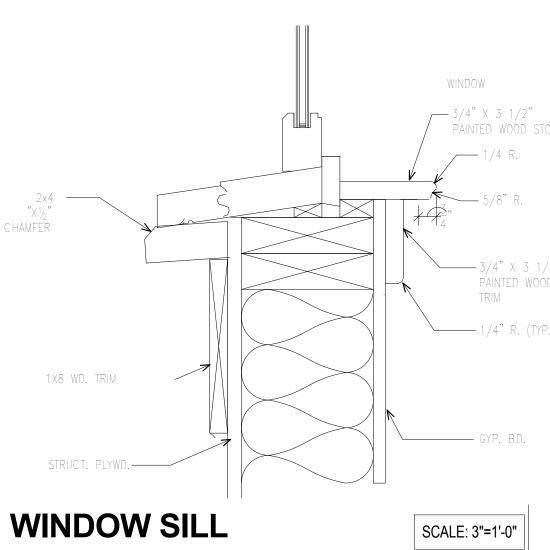

2x4 "X1/2" CHAMFER	WINE 3/4 PAI	00W 4" X 3 1/2" NTED WOOD ST — 1/4 R. — 5/8" R. — 3/4" X 3 1, PAINTED WOOTRIM
1X8 WD. TRIM  STRUCT. PLYWD.		- 1/4" R. (TYF
WINDOW SILL	SCALE:	3"=1'-0"

**WINDOW JAMB DETAIL** 

Door Schedule							
Door				Finish			
Number	Door Type	Door Size	Description	Frame	Comments		
1	34	36" x 80"	EXTERIOR	1 3/4"			
2	23	36" x 80"	INTERIOR	1 3/8"			
3	23	36" x 80"	INTERIOR	1 3/8"			
6	3	72" x 80"	SLIDING CLOSET	1 3/8"			
7	3	72" x 80"	SLIDING CLOSET	1 3/8"			
8	23	36" x 80"	INTERIOR	1 3/8"			
9	23	36" x 80"	INTERIOR	1 3/8"			
10	23	36" x 80"	INTERIOR	1 3/8"			
11	62	72" x 82"	SLIDING GLASS	1 3/4"			
12	23	36" x 80"	INTERIOR	1 3/8"			
13	39	24" x 80"	INTERIOR	1 3/8"			
14	39	24" x 80"	INTERIOR	1 3/8"			
15	22	30" x 80"	EXTERIOR	1 3/4"			


			Wi	indow Schedule			
	Rough Opening				Glazing	Head	
Type Mark	Width	Height	Type	Material	Туре	Height	Comments
В	4' - 0"	4' - 0"	Slider with Trim	VINYL		6' - 8"	
С	3' - 0"	2' - 0"	Slider with Trim	VINYL		6' - 8"	
D	4' - 0"	3' - 0"	Slider with Trim	VINYL		6' - 8"	
G	5' - 0"	3' - 0"	Slider with Trim	VINYL		6' - 8"	
Н	1' - 4"	4' - 0"	Fixed with Trim	VINYL		6' - 8"	

		Lighting Fixture Schedule	е		
Type Mark	Family and Type	Manufacturer	Model	Lamp	Type Comments
	Ceiling Light - Flat Round: 60W - 120V			A-19	
	Outdoor_Wall_Sconce_Wall_Mount : CB3325-2N75(120V)[BC BL][TC TL]		CB3325	75W MED A19 Incandescent	

			Room Fi	nish Schedu	ıle	
Room			Fi			
Number	Room Name	Floor	Base	Wall	Ceiling	Comments
_		T	I	0) (2 2 2		
1	GREAT ROOM	Vinyl/Laminate	4" MDF Painted	GYP BD	GYP BD ceil. hgt varries	orange peel finish all walls and ceiling
2	BEDROOM 1	Carpet	4" MDF Painted	GYP BD	GYP BD ceil hgt 8'	orange peel finish all walls and ceiling
3	LAUNDRY	Vinyl/Laminate	4" MDF Painted	GYP BD	GYP BD ceil hgt 8'	orange peel finish all walls and ceiling
4	Bath 2	Vinyl/Laminate	4" MDF Painted	GYP BD	GYP BD ceil hgt 8'	orange peel finish all walls and ceiling
5	BATH	Vinyl/Laminate	4" MDF Painted	GYP BD	GYP BD ceil hgt 8'	orange peel finish all walls and ceiling
6	BEDROOM 2	Carpet	4" MDF Painted	GYP BD	GYP BD ceil hgt 8'	orange peel finish all walls and ceiling
7	Linen	Vinyl/Laminate	4" MDF Painted	GYP BD	GYP BD ceil hgt 8'	orange peel finish all walls and ceiling

# **JMB ARCHITECTURE** ARCHITECTURE **PLANNING**

4767 HIGHWAY 96 PO BOX 1170 WILLOW CREEK, CA 95573 707.629.0010 fax 707.629.2348 email: jmbarchitect@snowcrest.net

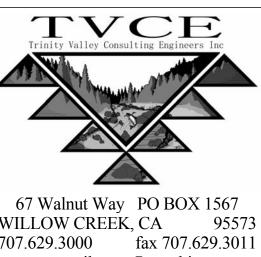

WILLOW CREEK, CA 95573 707.629.3000 fax 707.629.3011 email: tvce@tvce.biz

Electrical Consultant Pace Engineering


1730 South Street Redding, CA 96001 530 244-0202


Abbay Technical Services Anny McQuenny 1125 16th Street, Ste. 216 Arcata, CA 95521 707.826.1433 Bldg. Energy Consultant Address Phone Fax e-mail 707-826-1430

anny@ abbaytechnicalservices.com

No.	Description	Date
·	Schedule	20
Project nu	mber	ktha 201
Project nu	mber	ktha 201 07/05/201
	mber	
Date		07/05/201
Date Drawn by		07/05/20 RKH



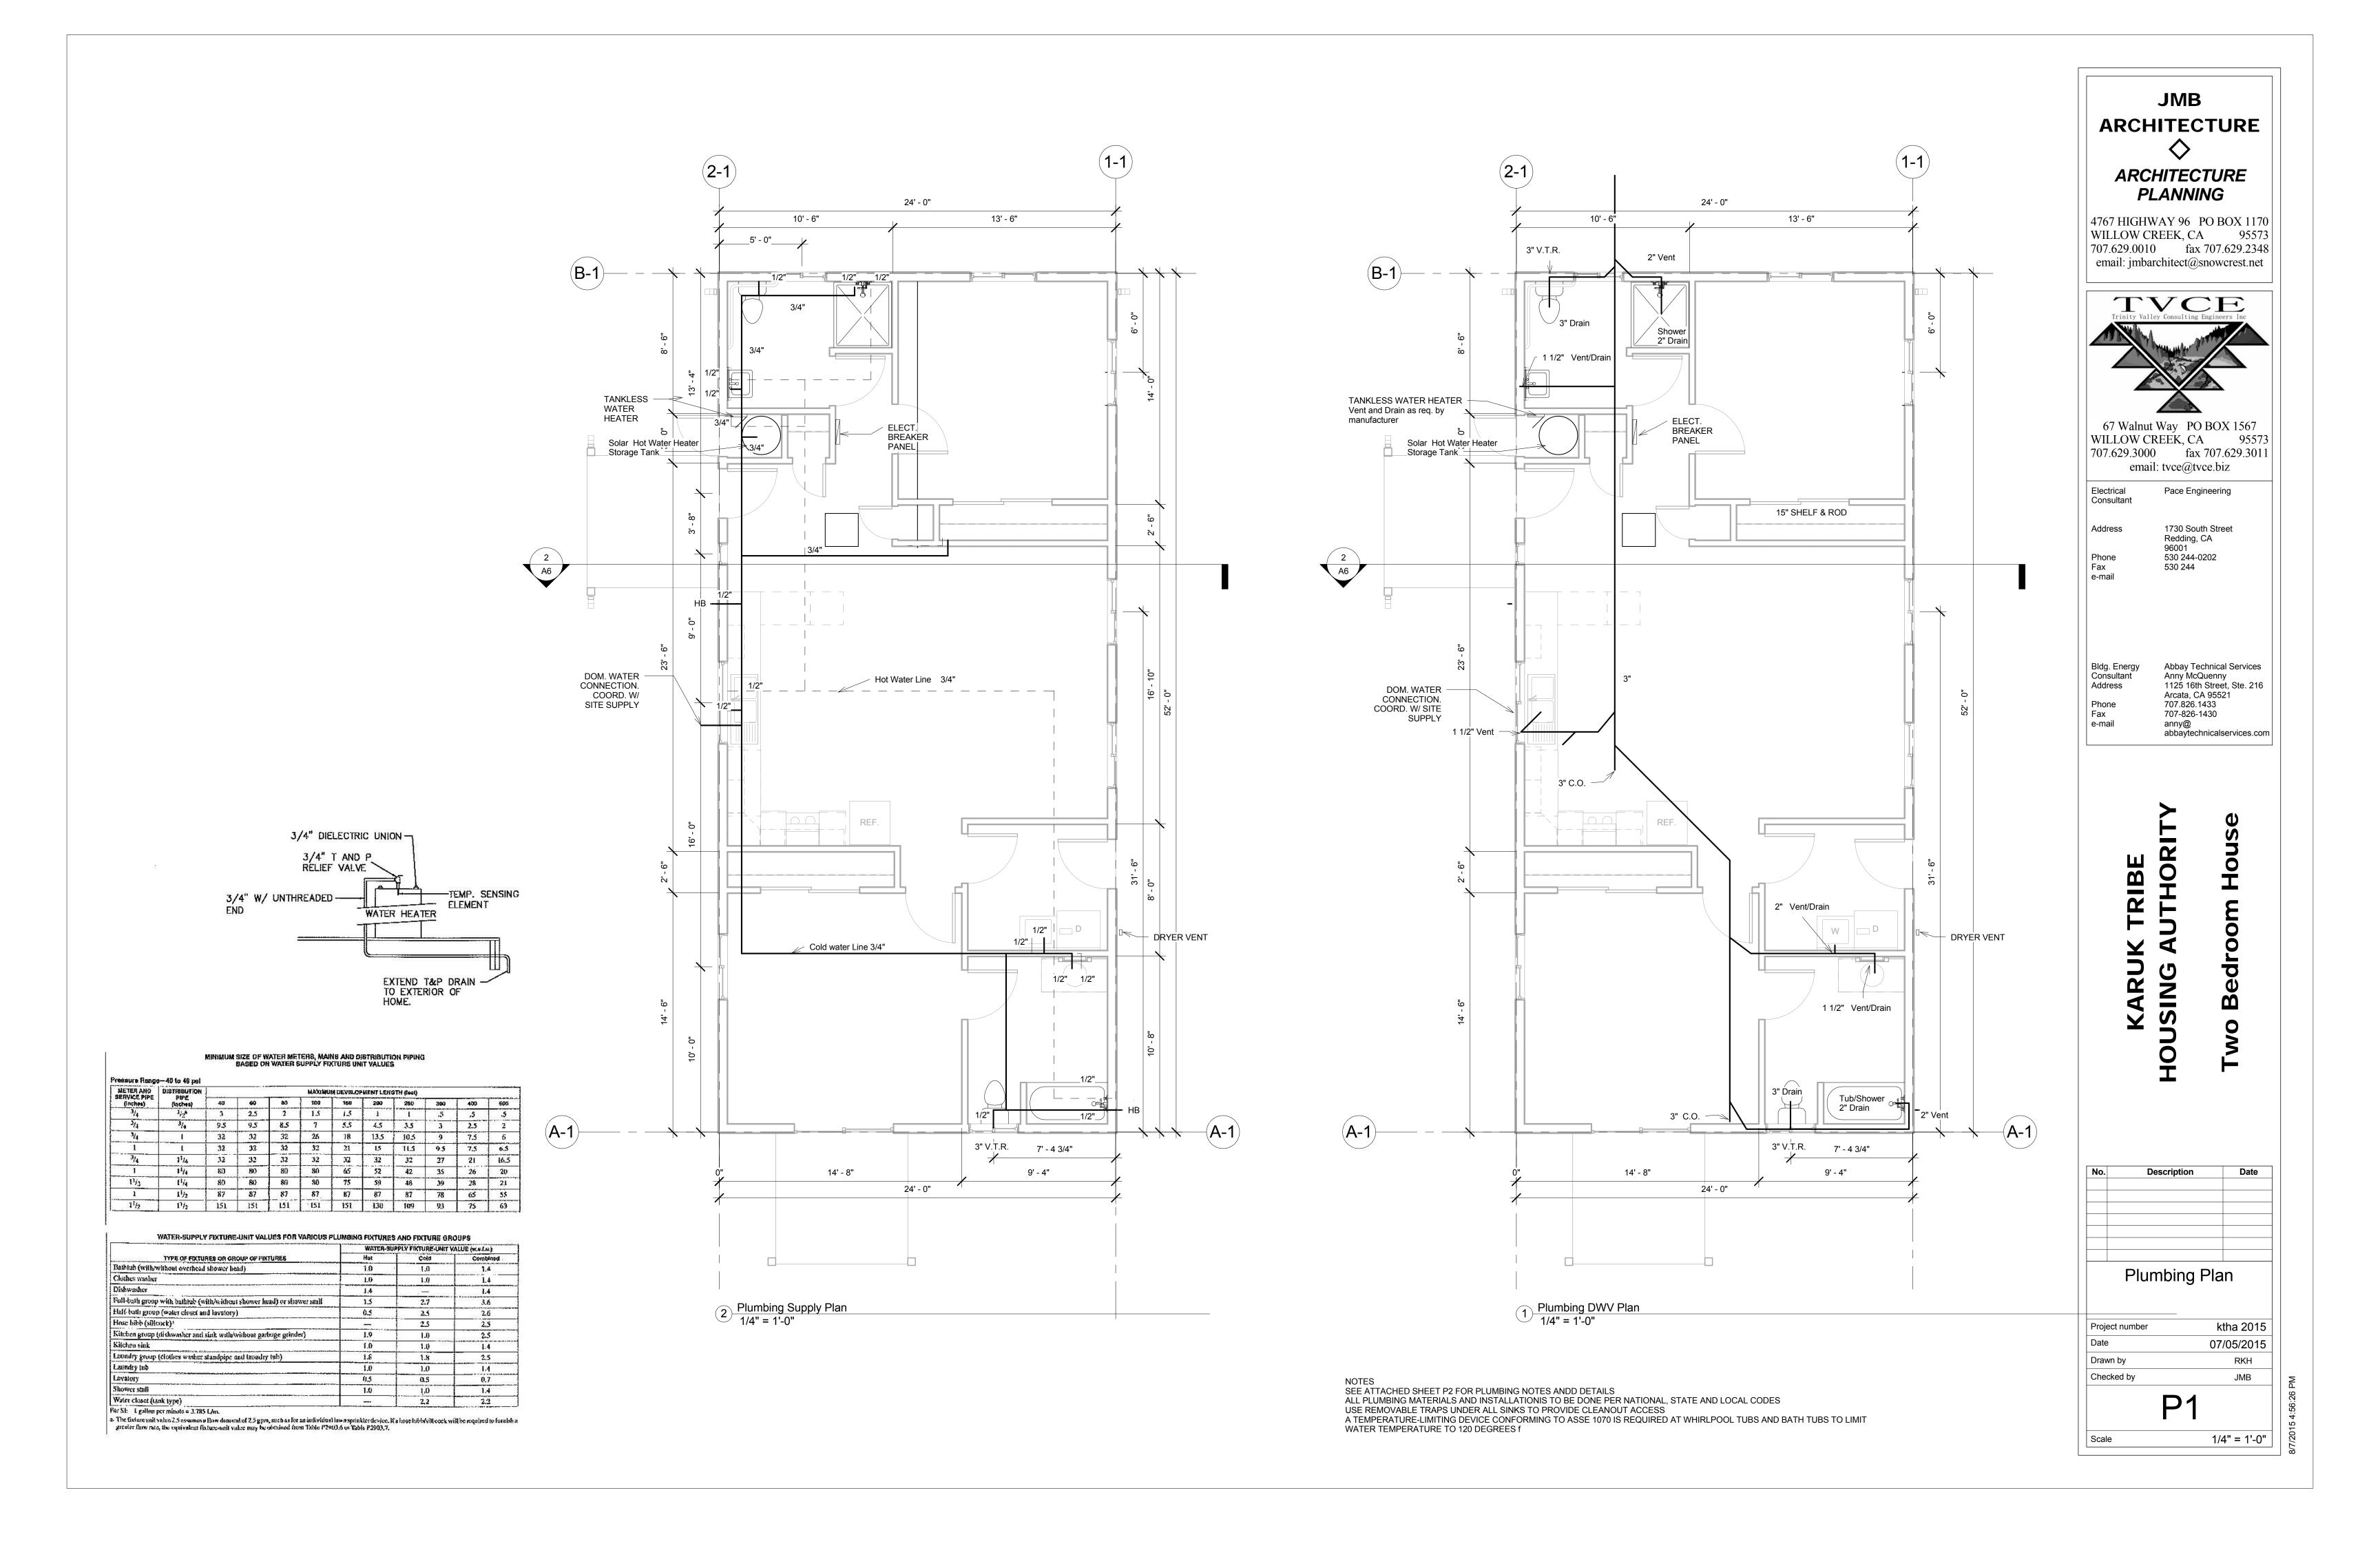

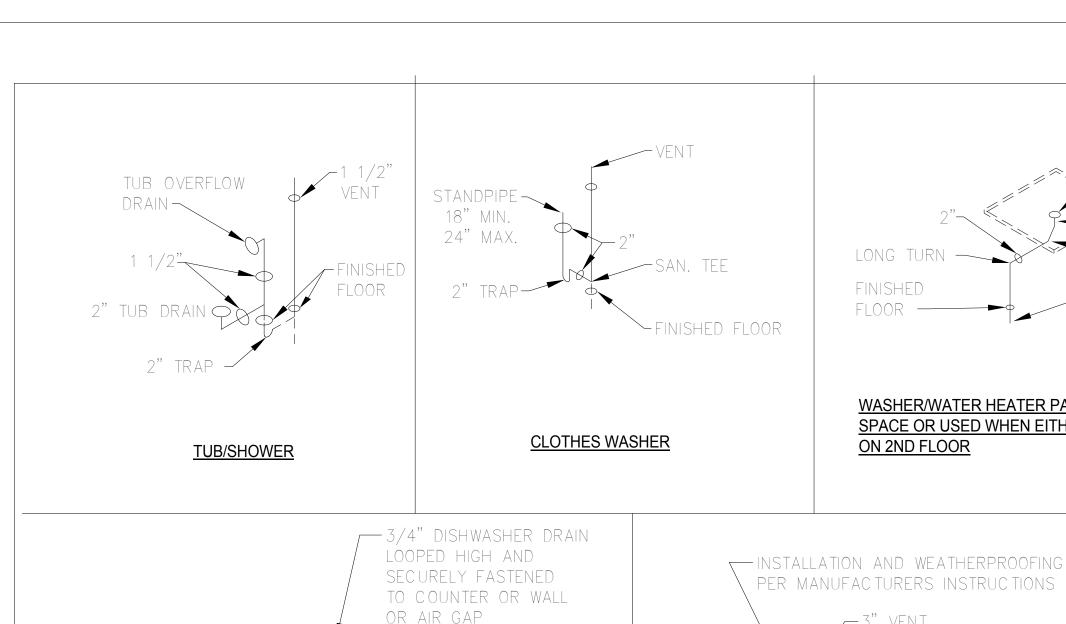

WYE-BRANCH

1. ALL WASTE AND VENT LINES ARE TO BE ABS OR PVC PIPE PROVIDED DWELLING DOES NOT

3. WASTE LINES: INSTALL WYE W/ CLEANOUT PRIOR TO EXITING WALL FOR CONNECTION TO

2. PITCH ON HORIZONTAL WASTE LINES SHALL BE 1/4". IF A SPECIAL CONSTRUCTION CONDITION

4. PVC-DWV PIPE SUPPORTS: AT BRANCHES, CHANGES IN DIRECTION AND AT THE BASE, EACH FLOOR AND MID STORY (VERTICAL) MAXIMUM EVERY 3'-0" AT THE END OF BRANCHES, AND CHANGE OF DIRECTION OR ELEVATION. 4" MINIMUM MAIN WASTE TO SEPTIC (BY BUILDER).

5. PLASTIC PIPE SHALL NOT PENETRATE FIRE RATED ASSEMBLIES INCLUDING FLOOR/CEILING. PIPING

6. EACH DWELLING SHALL HAVE ONE MAIN 3 INCH MIN. STACK FROM BUILDING DRAIN AND AT A

SHALL BE FIRESTOPPED WHERE REQUIRED WITH MATERIAL EQUIVALENT TO CONSTRUCTION WHICH IT PENETRATES & BE SUITABLE TO PIPE MATERIAL OR USE METAL PIPE FROM A MIN. OF ABOVE

EXISTS, LOCAL AUTHORITIES MAY GIVE APPROVAL FOR 1/8" SLOPE ON PIPE DIAMETERS OF 4"

FITTING

KITCHEN SINK/DISHWASHER/DISPOSAL

EXCEED TWO STORIES IN HEIGHT. SUPPLY LINES ARE TO BE COPPER.

7. ALL TRAP ARMS MUST BE SUPPORTED WITH 3/4" MINIMUM BEARING.


GARB AGE

<u>DWV N</u>OTES:

ASSEMBLY & DOWN.


PLUMBING CODES

MIN. OF 6" ABOVE THE ROOF LINE

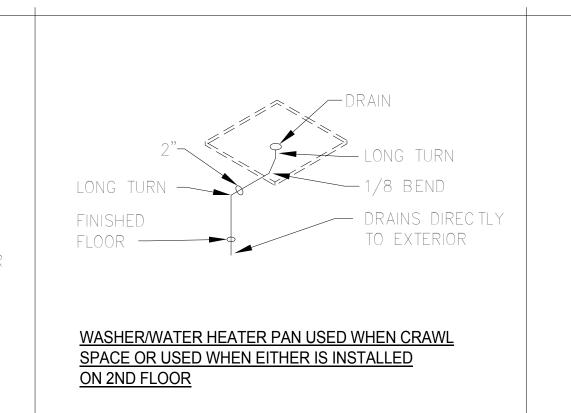

PER MANUFACTURERS INSTRUCTIONS


VENT THRU ROOF DETAIL

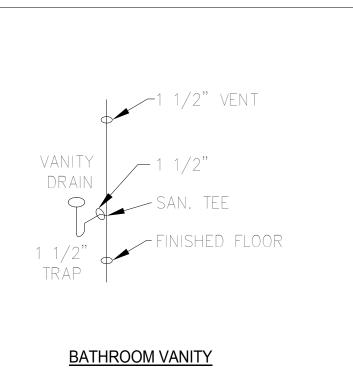

SHOWER

**SHOWER** 

TEE WYE —

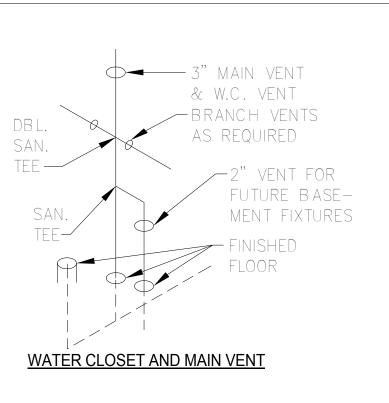




**JMB** 

**ARCHITECTURE** 

WILLOW CREEK, CA 95573 707.629.0010 fax 707.629.2348 email: jmbarchitect@snowcrest.net

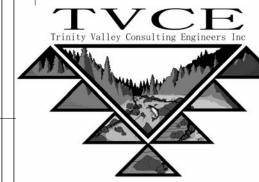

67 Walnut Way PO BOX 1567 WILLOW CREEK, CA 95573 707.629.3000 fax 707.629.3011 email: tvce@tvce.biz

Pace Engineering Consultant

Fax

Phone

e-mail

RB

AR

SING

---- VENT EXTENSION

FROST CLOSURE

LONG SWEEP OR

SHORT SWEEP

SEE NOTES) -

PIPE INCREASER

REDUCER (OCCURS

MIN 12" BELOW ROO


1730 South Street Redding, CA 96001 530 244-0202 530 244

Address

Arcata, CA 95521 707.826.1433 707-826-1430 anny@


Abbay Technical Services Anny McQuenny 1125 16th Street, Ste. 216

abbaytechnicalservices.com

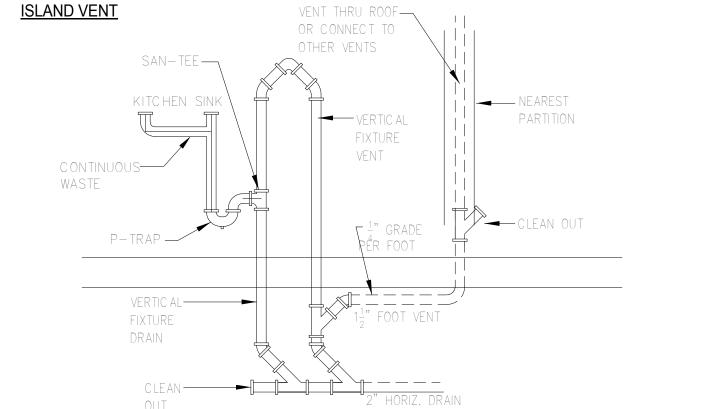

1 1/2" VENT

-FINISHED FLOOR

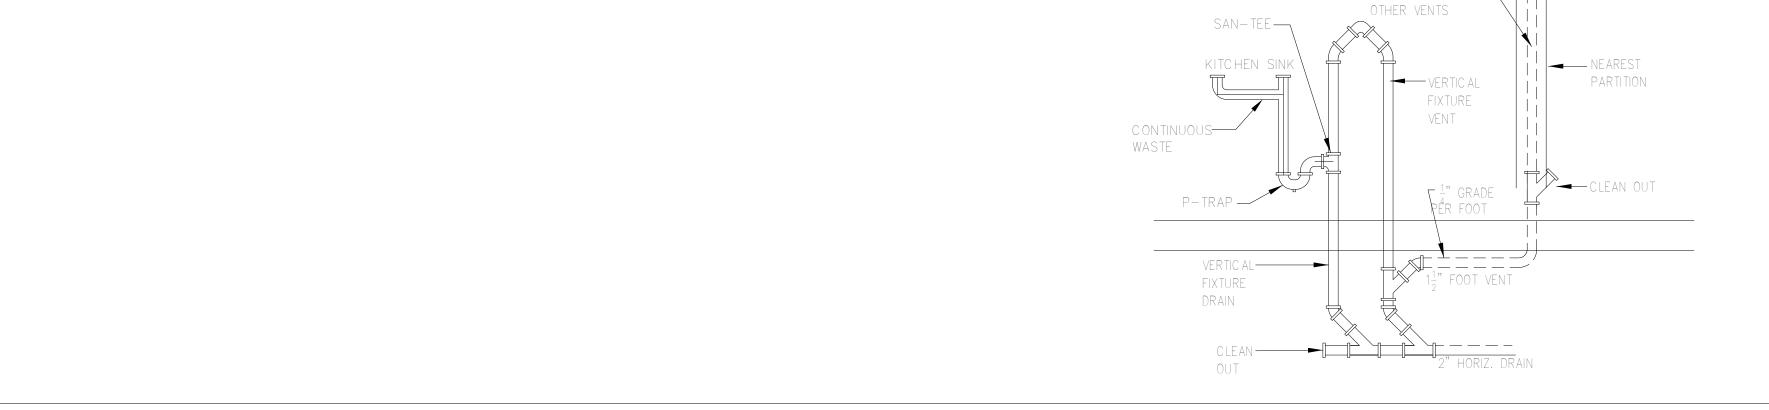

KITCHEN SINK/DISHWASHER/DISPOSAL

WYE WITH

1 1/2" VENT

FINISHED FLOOR

SHOWER

**SHOWER** 

1/4 BEND

DOUBLE 1/4 BEND 7 SEE NOTE 10

LONG TURN

DRAIN LINE

 
KITCHEN SINK/DISHWASHER DETAIL

8. ALL PLASTIC PIPE MUST BE SUPPORTED AT INTERVALS IN ACCORDANCE WITH APPLICABLE 9. HORIZONTAL TO HORIZONTAL & VERTICAL TO HORIZONTAL DRAIN CHANGES IN DIRECTION SHALL BE 45 DEGREE WYES, LONG SWEEP 90 DEGREE ELBOWS, LONG SWEEP TY'S, 6TH., 8TH. OR 16TH BENDS, APPROVED COMBINATIONS OF THESE OR EQUIVALENT LONG SWEEP FITTINGS. SHORT SWEEPS PERMITTED IN SINGLE BRANCH HORIZONTAL TO VERTICAL CHANGES IN DIRECTION ON 3

WITH 1/8 BEND-


1/8 BEND-


- INCH OR LARGER. 10. TRAPS SHALL BE PLACED AS CLOSE AS POSSIBLE TO FIXTURE OUTLET. MAXIMUM VERTICAL DROP FROM FIXTURE OUTLET TO TRAP WEIR IS 24"
- 11. INACCESSIBLE TRAPS SHALL NOT HAVE UNIONS, CLEANOUTS OR SLIPJOINTS. ACCESSIBLE TRAPS SHALL BE REMOVABLE WITH UNION IN TRAP SEAL OR HAVE CLEANOUT OPENING SAME SIZE AS TRAP.
- 12. ALL HORIZONTAL VENT BRANCH PIPING SHALL BE LOCATED A MINIMUM OF 6" ABOVE THE FLOOD LEVEL OF THE HIGHEST FIXTURE IN THAT BRANCH.
- 13. MAXIMUM DISTANCE OF FIXTURE TRAP WEIR TO VENT SHALL BE IN ACCORDANCE WITH ALL APPLICABLE PLUMBING CODES.
- 14. PLASTIC PIPING SHALL BE PROTECTED WITH 1/16" (15 GAUGE) STEEL PLATE WHEN PIPE PASSES THRU WOOD MEMBERS LESS THAN 1 1/4 INCHES FROM EDGE OF MEMBER. CPC 2001 313.9
- 15. FALL IN TRAP NOT ACCEPTABLE IN CPC
- 16. THE VENT PIPE OPENING FROM A SOIL OR WASTE PIPE, EXCEPT FOR WATER CLOSET AND SIMILAR FIXTURES, SHALL NOT BE BELOW THE WEIR OF THE TRAP. CPC 2001 1002.4



TEE WYE -

- 18. POTABLE WATER SYSTEM SHALL BE DISINFECTED ON SITE BY SITE BUILDER IN ACCORDANCE WITH APPLICABLE STATE PLUMBING CODES
- 19. BACKFLOW DEVICES, VACUUM BREAKERS & AIR GAPS: FOR WATER DISTRIBUTION SYSTEMS "PROTECTION OF POTABLE WATER SUPPLY.
- A.- WATER HEATER LOCATED @ OR ON LIVING SPACE LEVEL MUST HAVE A BACKFLOW DEVICE INSTALLED AND MUST HAVE A WATERTIGHT PAN OF CORRISON RESISTANT MATERIALS INSTALLED.
- B.- CLOTHES WASHER (IF NOT BUILT IN TO THE APPLIANCE) MUST HAVE AN BACKFLOW 20. WAYTER HEATTER FAND FURNACE SHALL BE BRACED TO SECURE AGAINST SEISMIC MOVEMENTS. USE PLUMBER TAPE BRACING OR OTHER APPROVED FASTENERS.

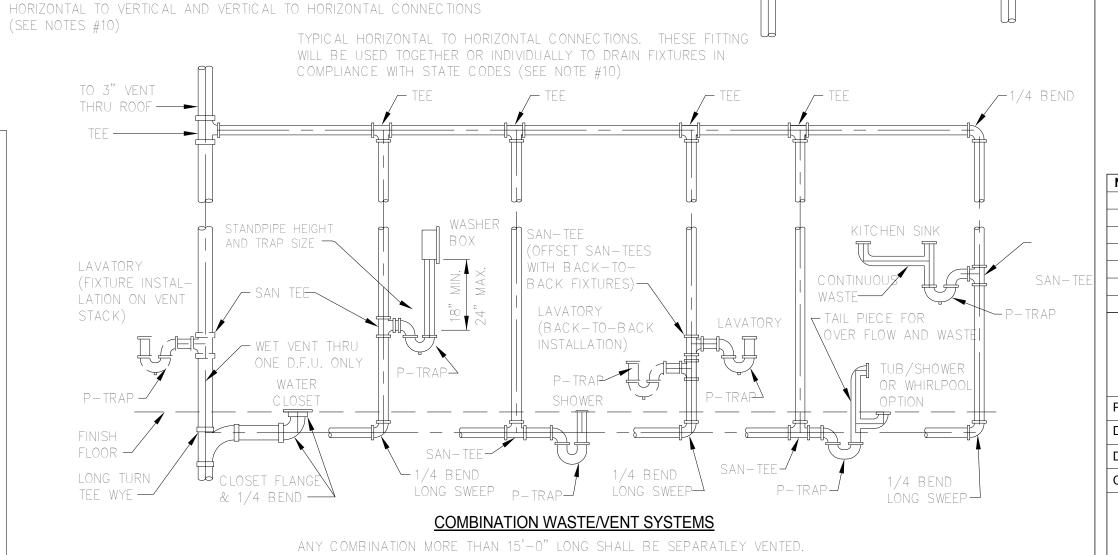

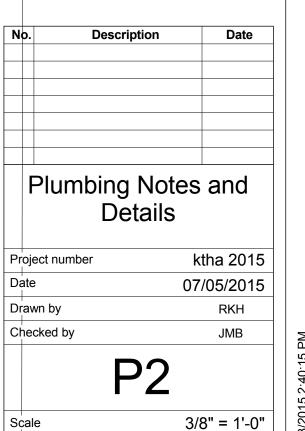

\_\_\_\_5' - 0"\_\_\_\_\_ TANKLESS -WATER HEATER ELECT. BREAKER Solar Hot Water Heater Storage Tank PANEL Heat pump Return Air Air Handler in attic DOM. WATER CONNECTION. COORD. W/ SITE SUPPLY DRYER VENT 14' - 8"

Mechanical Plan
1/4" = 1'-0"

JMB
ARCHITECTURE

# ARCHITECTURE PLANNING

4767 HIGHWAY 96 PO BOX 1170 WILLOW CREEK, CA 95573 707.629.0010 fax 707.629.2348 email: jmbarchitect@snowcrest.net



67 Walnut Way PO BOX 1567 WILLOW CREEK, CA 95573 707.629.3000 fax 707.629.3011 email: tvce@tvce.biz

Electrical Pace Engineering Consultant

Address 1730 South Street
Redding, CA
96001
Phone 530 244-0202

96001 Phone 530 244-020 Fax 530 244 e-mail

Bldg. Energy
Consultant
Anny McQuenny
Address
1125 16th Street, Ste. 216
Arcata, CA 95521
Phone
707.826.1433

Phone 707.826.1433
Fax 707-826-1430
e-mail anny@ abbaytechnicalservices.com

# KARUK TRIBE JSING AUTHORITY

).	Description	Date

Mechanical Plan

Project number ktha 2015

Date 07/05/2015


Drawn by RKH


Checked by JMB


Scale 1/4" = 1'-0"

DISCLAIMER:
HEATING PLANS ARE SHOWN FOR REPRESENTATION ONLY.
HEATING AND COOLING SYSTEMS WILL BE DESIGNED AND INSTALLED BY THE HEATING SYSTEM SUPPLIER
AND WILL BE REVIEWED AND APPROVED BY LOCAL JURISDICTIONS HAVING AUTHORITY

NOTES:
1. UNIT TO BE BRYANT OR EQUAL WITH THE AIR HANDLER IN THE ATTIC AND HEAT PUMP OUTSIDE ON GROUND.
2. FLEX DUCTING
3. ALL AIR DISTRIBUTION SYSTEMS, DUCTS, PLENUMS AND OTHER EQUIPMENT SHALL BE
DESIGNED AND INSTALLED IN ACCORDANCE WITH CMC AND UL 181 STANDARDS.
4. BUILDING HEATING AND COOLING LOADS SHALL BE DETERMINED USING THE ASHRAE OR SMACNA STANDARDS.
5. ALL DUCT SEAL AND INSULATION SHALL MEET THE CENC REQUIREMENTS.
6. ALL METAL DUCTS FOR STATIC AIR PRESSURE SHALL COMPLY WITH TABLE 6-1 2001 CMC

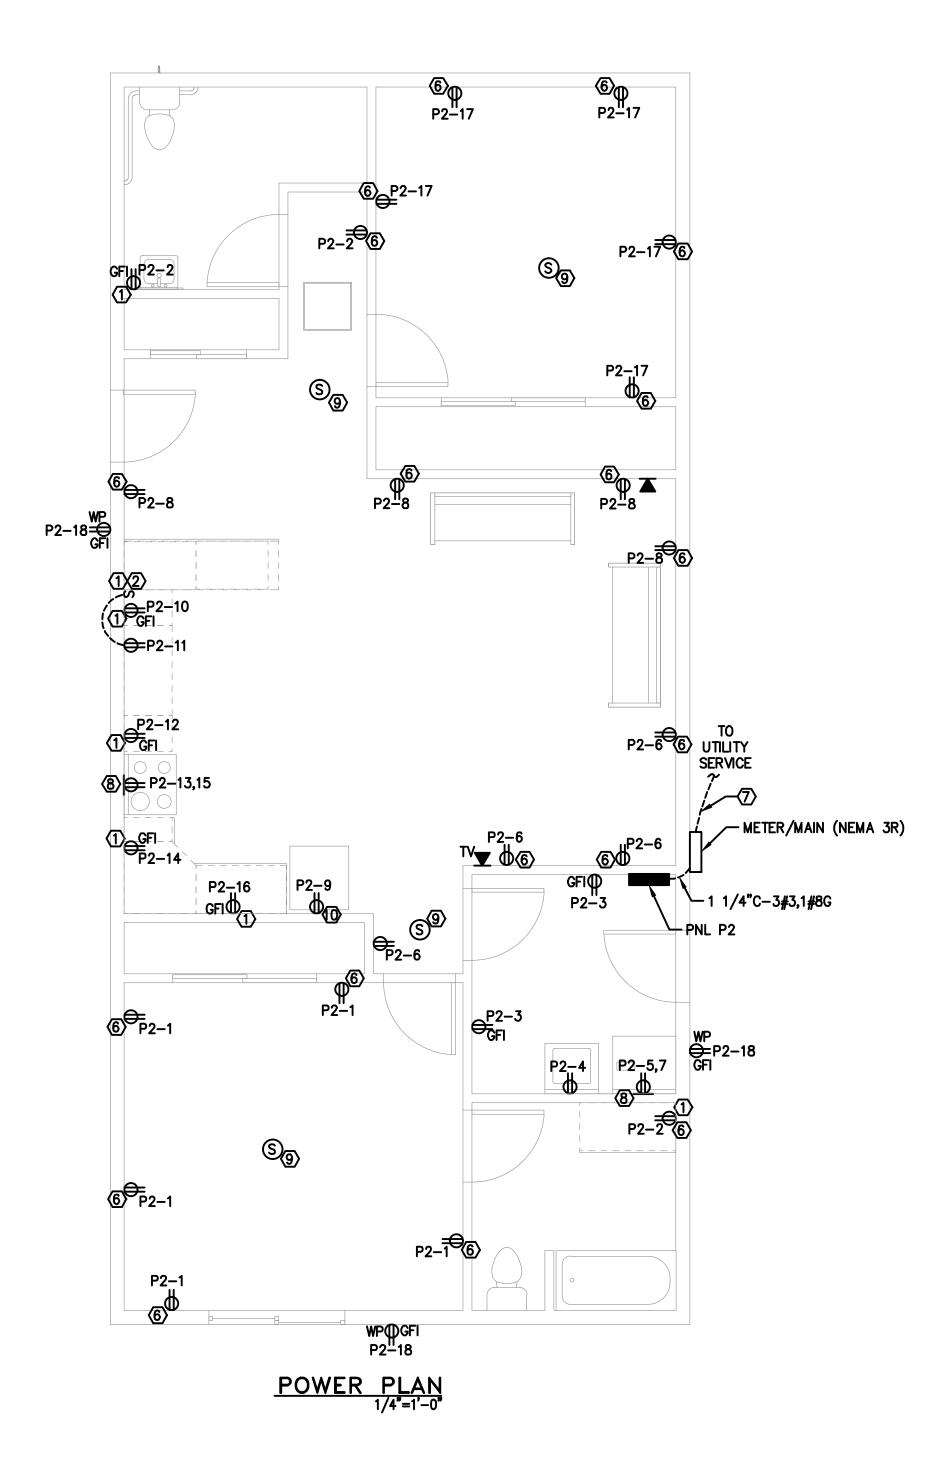

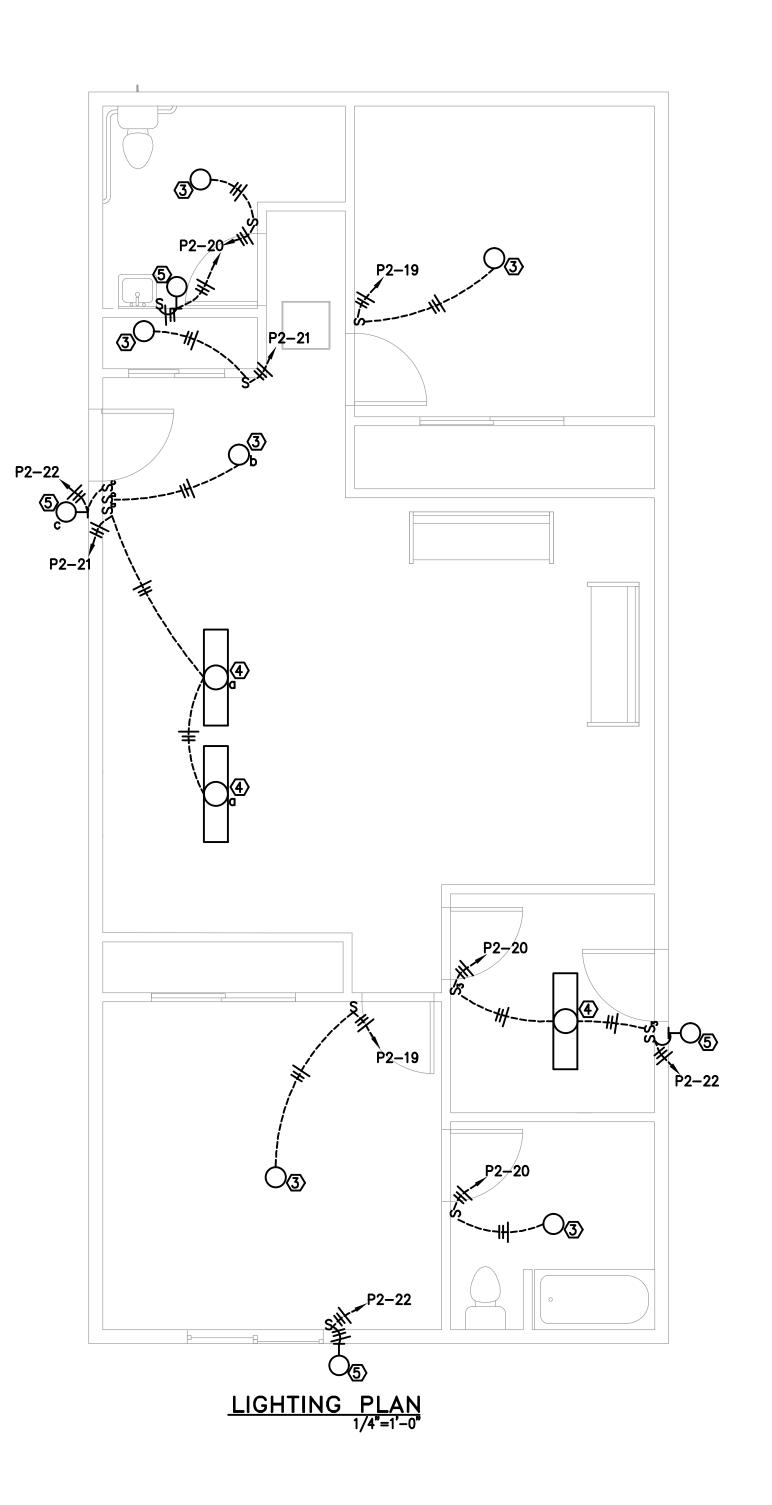

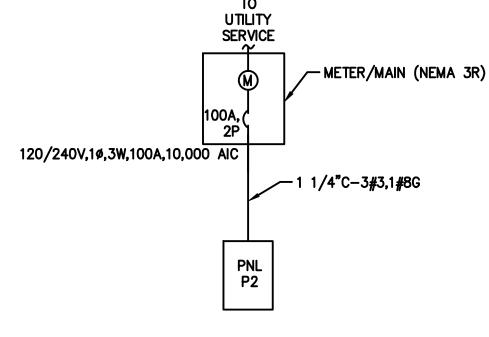


### ONE-LINE DIAGRAM

### **GENERAL NOTES**

- 1. UNLESS OTHERWISE INDICATED, RECEPTACLES AND JUNCTION BOXES SHALL BE CONNECTED TO THE CIRCUIT INDICATED USING 1/2" C-2#12,1#12G. RECEPTACLE CIRCUITS SHALL BE CONCEALED IN WALLS OR ABOVE CÉILINGS.
- 2. MAINTAIN A MINIMUM  $30"W \times 36"D$  CLEAR SPACE IN FRONT OF ALL ELECTRICAL DISCONNECTS AND PANELS PER THE CEC.
- 3. MAINTAIN WORKING SPACE AND 6'-6" HEAD ROOM IN FRONT OF ALL ELECTRICAL EQUIPMENT IN ACCORDANCE WITH CEC.
- 4. CONDUCTORS SHALL BE NON-METAL SHEATHED CABLE (ROMEX) UNLESS OTHERWISE SHOWN.
- 5. RECEPTACLES SHALL BE SPECIFICATION GRADE WITH NUMBER OF POLES AS REQUIRED. RECEPTACLES SHALL BE PROVIDED WITH GROUND TERMINALS AND SCREW TERMINALS SUITABLE FOR NO. 10 CONDUCTORS. RECEPTACLES SHALL BE WHITE AND RATED FOR 15A, 120V WITH A NEMA 5-15R CONFIGURATION. DEVICE PLATE SHALL BE PLASTIC WITH COLOR TO MATCH RECEPTACLES.
- 6. PANELBOARDS SHALL BE RATED AS SHOWN AND PROVIDED WITH TIN-PLATED ALUMINUM BUS, THERMAL MAGNETIC CIRCUIT BREAKERS AS SHOWN, AND NEMA 1 ENCLOSURE UNLESS OTHERWISE INDICATED.

### KEY NOTES

- 1 PROVIDE AND INSTALL RECEPTACLE 6" ABOVE COUNTER HEIGHT.
- ② SWITCHED GARBAGE DISPOSAL RECEPT.
- $\bigcirc$  A-19 INCANDESCENT LIGHT FIXTURE TO BE DETERMINED.
- 4 2 TUBE, F32W T8 SURFACE MOUNT FLUORESCENT FIXTURE.
- (5) WALL SCONCE LIGHT FIXTURE TO BE DETERMINED.
- 6 ARC FAULT RECEPT.
- (7) PROVIDE AND INSTALL IN ACCORDANCE WITH UTILITY REQUIREMENTS.
- (8) PROVIDE RECEPTACLES TO MATCH EQUIPMENT CONFIGURATION.
- (9) PROVIDE AND INSTALL SMOKE DETECTOR IN LOCATION SHOWN.
- (D) PROVIDE AND INSTALL RECEPTACLE 48" ABOVE FINISHED FLOOR.

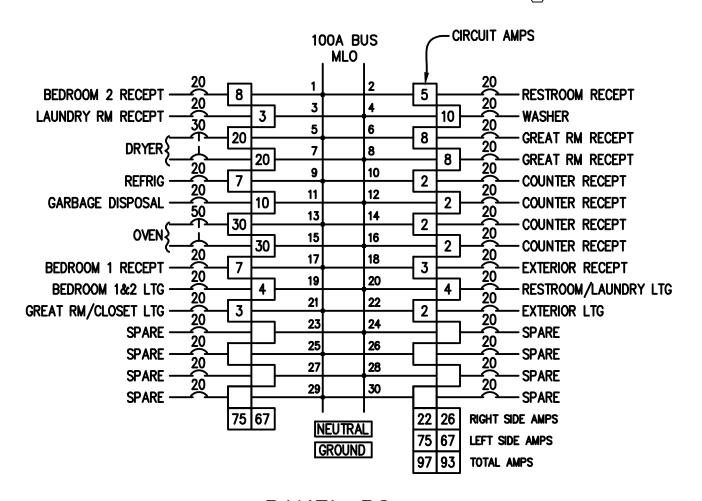

PANEL P2 VOLTAGE: 120/240V LOCATION: LAUNDRY RM MOUNTING: SURFACE AMPS IC: 10,000

### **ELECTRICAL SYMBOLS**

----- CONDUIT EXPOSED ---- CONDUIT CONCEALED or BURIED

CROSSHATCHES ON CONDUIT RUN INDICATES
NUMBER OF #12 CONDUCTORS

SUBSCRIPT G INDICATES GREEN GROUND CONDUCTOR

— LA-2 HOME RUN-DESTINATION SHOWN

SURFACE MOUNT PANELBOARD LUMINAIRE

LUMINAIRE WALL MOUNTED LUMINAIRE

TYPE INDICATED SEE LUMINAIRE AND DEVICE SCHEDULE So or SMALL LETTER SUBSCRIPT AT SWITCH AND LUMINAIRE INDICATES SWITCHING

CONVENIENCE RECEPTACLE. DUPLEX WP-WEATHERPROOF UNLESS SPECIFIED OTHERWISE AFCI-ARCH FLASH

4-PLEX CONVENIENCE RECEPTACLE CURRENT INTERRUPTER MOUNT 15" AFF FROM THE GFI-GROUND FAULT BOTTOM OF THE RECEPT UNLESS OTHERWISE NOTED. INTERRUPTER

TELEPHONE/DATA RECEPTACLE (OUTLET BOX ONLY)

WALL SWITCH: MOUNT SWITCHES 48" AFF TO TOP OF DEVICE UNLESS OTHERWISE INDICATED. TYPE INDICATED SEE LUMINARE AND DEVICE SCHEDULE.

— CIRCUIT BREAKER, THERMAL MAGNETIC TRIP SHOWN, 3—POLE UNLESS INDICATED OTHERWISE



KARUK TRIBE HOUSING AUTHORITY 635 JACOBSON WAY HAPPY CAMP, CA 96039

TWO BEDROOM FLOOR PLAN

SHEET